



	SHEET LIST	
PAGE	SHEET NAME	SCALE
1	COVER PAGE	N/A
2	EXISTING FLOOR PLAN	1:100
3	DEMOLISH FLOOR PLAN	1:100
4	PROPOSE FLOOR PLAN	1:100
5	FURNITURE PLAN	1:100
6	REFLECTED CEILING PLAN	1:100
7	ELECTRICAL PLAN	1:100
8	EXTERNAL ELEVATION	1:50
9	SECTION A & SECTION B	1:100
10	SECTION C & SECTION D	1:100
11	COUNTER INTERNAL PLAN	1:10
12	COUNTER ELEVATION A & B	1:10
13	COUNTER ELEVATION C & D	1:10
14	COUNTER SECTION A & COUNTER DETAIL	1:10 , 1:5
15	COUNTER SECTION B & COUNTER DETAIL	1:10 , 1:5
16	ISOMETRIC VIEW OF CAFE COUNTER	1:10
17	INTERNAL PLAN OF SEATING COUNTER	1:10
18	ELEVATION A & ELEVATION B OF SEATING COUNTER	1:10
19	ELEVATION C & ELEVATION D OF SEATING COUNTER	1:10
20	SECTION 1 & DETAIL 1 OF COUNTER	1:10 , 1:2
21	ISOMETRIC VIEW OF SEATING COUNTER	1:10
22	ISOMETRIC VIEW OF BUILDING	1:100

and measurements as well as site, conditions and notifying the designer of all discrepancies and omissions before commencing the works. - Submitting samples and shop drawings for review and approval by designer before commencing works. - Ensuring that all work is keeping with all International building codes. - All necessary repairs, patching and cleaning of site during and after completition of works. - Verifying existing site conditions prior to submissions of quotations. - Not starting the construction unless these drawings are signed approved. - All work specified on all drawings and specifications and supplying all necessary materials and labour required to complete all phases of work in accordance with the designer's standards.

The contractor to be responsible for:

- Verifying all drawings, specifications, dimensions

SPECIFIC NOTES: Location: 105,St.432,Toul Tompuong,

- All dimensions in millimeters

Phnom Penh, Cambodia

The co-working space is located in Toul Tompuong area which surrounded with Design company, Furniture store, Famous

cafes and Russian market that is tourist attraction area. The user will be Architect, Designer and

foreigners. It's the perfect location for them as the designer.

A DETAIL NO.

B SHEET NO.

NO. DATE: REVISIONS: ASSIGNMENT TITLE: DOCUMENTATION

DRAWING TITLE: COVER

PROJECT (FINAL)

NAME: BUNHANGLINA YEA

COURSE: SYSTEM AND DOCUMENTATION 3

TERM: 1


ASSIGNMENT NO.:4


LECTURER : SOPHIE LUCAS

DATE: 10 MAY 2020

SHEET:

SCALE: N/A

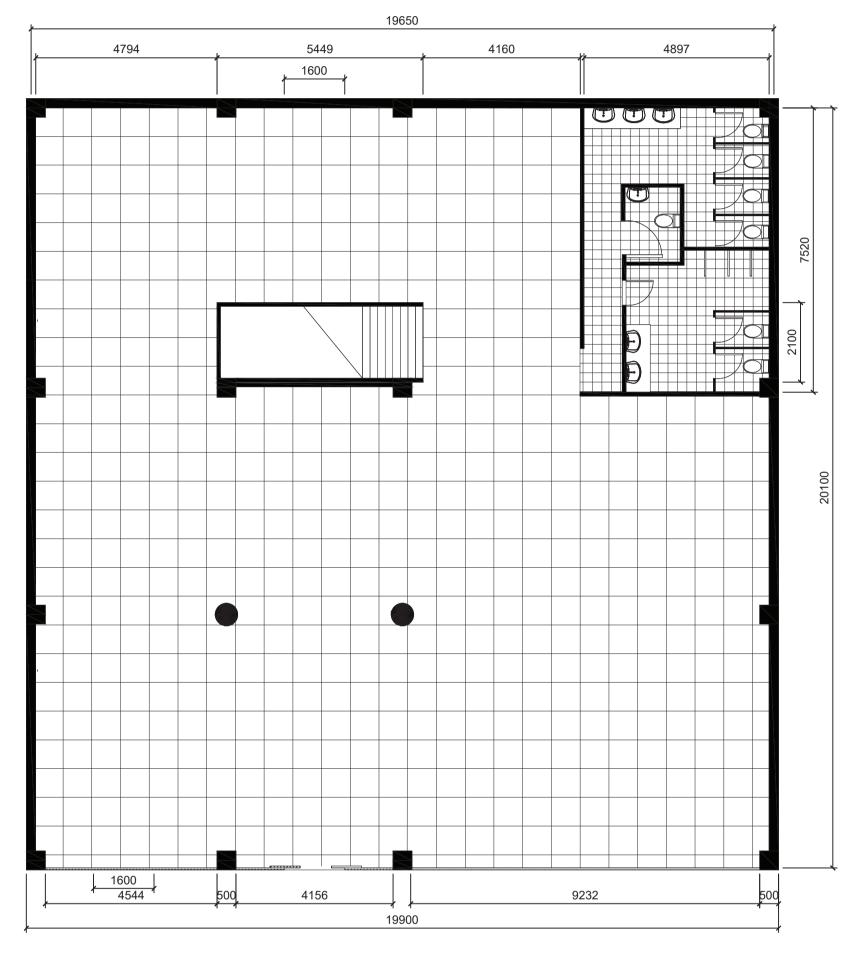

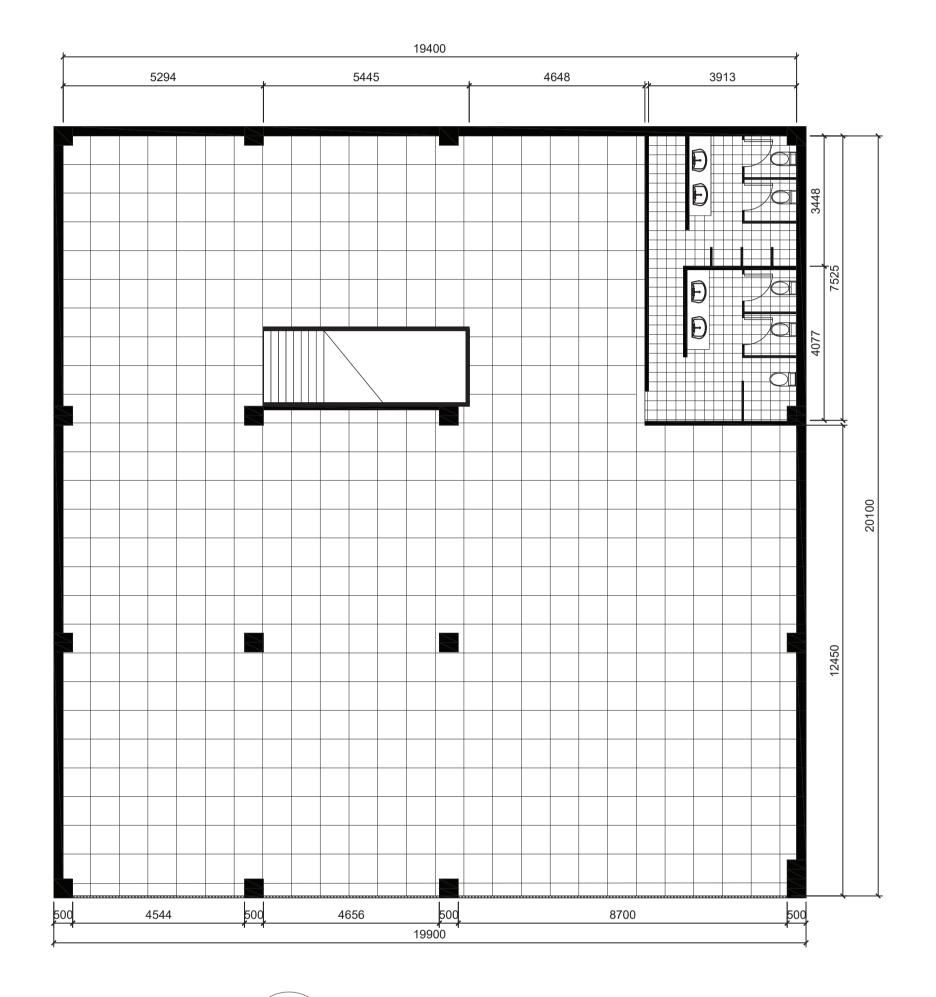

1 EXISTING FLOOR PLAN LEVEL 1
2 SCALE 1:100

2 EXISTING FLOOR PLAN LEVEL 2
2 SCALE 1:100

GENERAL NOTES

The contractor to be responsible for:
Verifying all drawings, specifications, dimensions and measurements as well as site, conditions and notifying the designer of all discrepancies and omissions before commencing the works.
Submitting samples and shop drawings for review and approval by designer before commencing works.
Ensuring that all work is keeping with all International building codes.

All necessary repairs, patching and cleaning of site during and after completition of works.
Verifying existing site conditions prior to submissions of quotations.

Not starting the construction unless these drawings are signed approved.
All work specified on all drawings and specifications and supplying all necessary materials and labour required to complete all

phases of work in accordance with the designer's

standards.
- All dimensions in millimeters

SPECIFIC NOTES:

A DETAIL NO.

B SHEET NO.

N

NO. DATE: REVISIONS:

ASSIGNMENT TITLE: DOCUMENTATION PROJECT (FINAL)

DRAWING TITLE: EXISTING PLAN

NAME: BUNHANGLINA YEA

COURSE: SYSTEM AND DOCUMENTATION 3


TERM: 1


ASSIGNMENT NO.:4

LECTURER : SOPHIE LUCAS

DATE: 9 MAY 2020

SCALE: 1:100

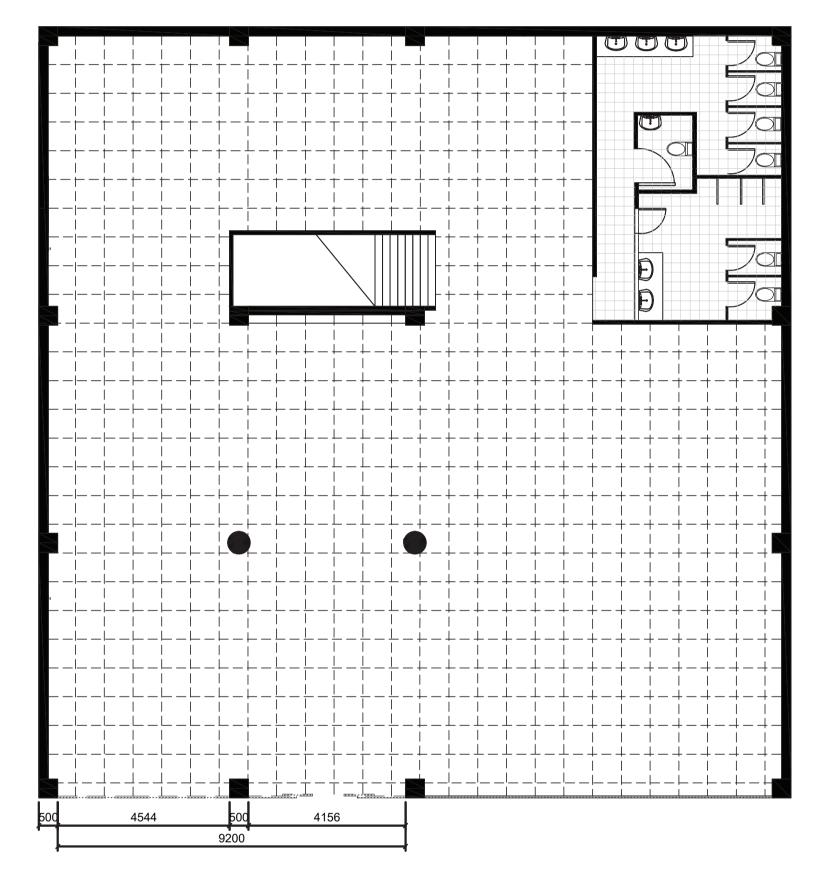

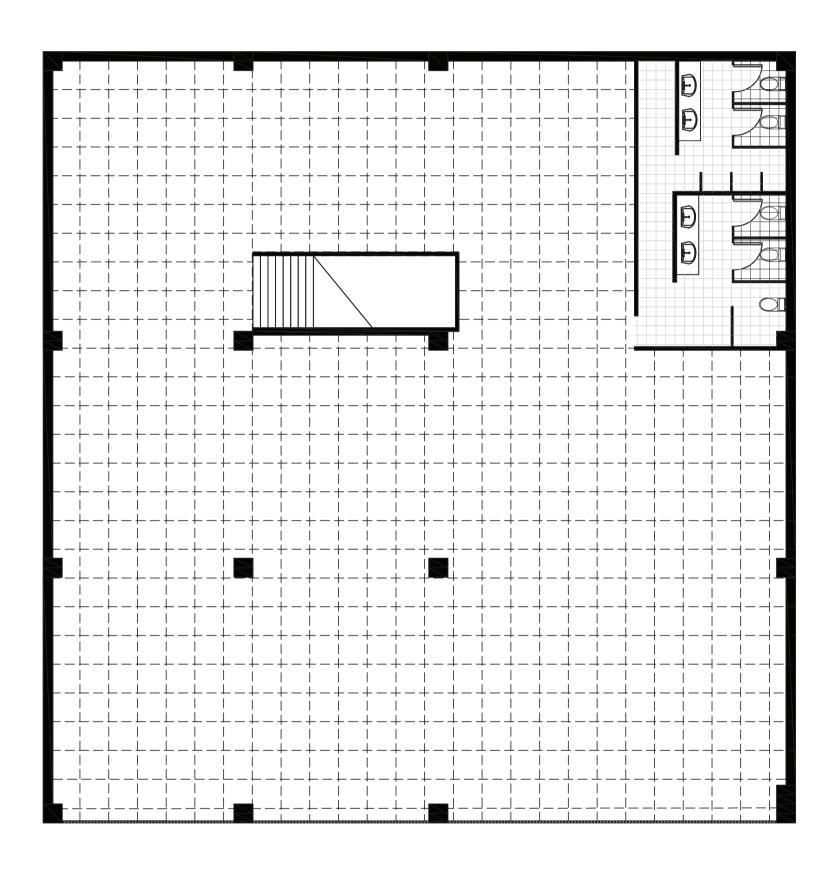

1 DEMO FLOOR PLAN LEVEL 1
3 SCALE 1:100

2 DEMO FLOOR PLAN LEVEL 2 3 SCALE 1:100 GENERAL NOTES

The contractor to be responsible for:
Verifying all drawings, specifications, dimensions and measurements as well as site, conditions and notifying the designer of all discrepancies and omissions before commencing the works.
Submitting samples and shop drawings for review and approval by designer before commencing works.
Ensuring that all work is keeping with all International building codes.
All necessary repairs, patching and cleaning of

site during and after completition of works.Verifying existing site conditions prior to submissions of quotations.Not starting the construction unless these

drawings are signed approved.

- All work specified on all drawings and specifications and supplying all necessary materials and labour required to complete all phases of work in accordance with the designer's standards.

All dimensions in millimeters

SPECIFIC NOTES:

DETAIL NO.

SHEET NO.

N

NO. DATE: REVISIONS:

ASSIGNMENT TITLE: DOCUMENTATION PROJECT (FINAL)

DRAWING TITLE: DEMOLISH PLAN

NAME: BUNHANGLINA YEA

COURSE: SYSTEM AND DOCUMENTATION 3

TERM: 1

ASSIGNMENT NO.:4

LECTURER : SOPHIE LUCAS

DATE: 9 MAY 2020

SCALE: 1:10

3



Verifying all drawings, specifications, dimensions and measurements as well as site, conditions and notifying the designer of all discrepancies and omissions before commencing the works.
Submitting samples and shop drawings for review and approval by designer before commencing works.
Ensuring that all work is keeping with all International building codes.
All necessary repairs, patching and cleaning of site during and after completition of works.
Verifying existing site conditions prior to submissions of quotations.
Not starting the construction unless these drawings are signed approved.
All work specified on all drawings and

specifications and supplying all necessary materials and labour required to complete all

phases of work in accordance with the designer's

The contractor to be responsible for:

standards.
- All dimensions in millimeters

SPECIFIC NOTES:

MATERIAL
DISCRIPTION
VINYL FLOORING,WOOD GRAIN TEXTURED,CLICK SYSTEM WITHOUT GLU
HERRING BONE LAMINATE FLOORING, SINGLE CLICK
TILE CARPET FROM SOFTFURNISHINGWORLD
WHITE GLOSSY FINISH CERAMIC TILE BACKSPLASH
20mm BLACK MARBLE TOP
20mm MDF BOARD WITH GRAY WOOD LAMINATE ON TOP
METAL CABINET HANDLE
MDF BOARD TOEKICK WITH METAL SHEET FINSIHES
15mm BLACK CHOCK BOARD
5mm TRANSPARENT GLASS
10MM MDF SHELVE BAORD
90X45mm SUPPORTING TIMBER BLOCK
W: 8mm, L:100, H: 1000mm, VERTICAL WOOD PANEL



NO. DATE: REVISIONS:

ASSIGNMENT TITLE: DOCUMENTATION PROJECT (FINAL)

DRAWING TITLE: PROPOSE FLOOR PLAN

NAME: BUNHANGLINA YEA

COURSE: SYSTEM AND DOCUMENTATION 3

TERM: 1


ASSIGNMENT NO.:4

LECTURER : SOPHIE LUCAS

DATE: 9 MAY 2020

SHEET:

SCALE: 1:10

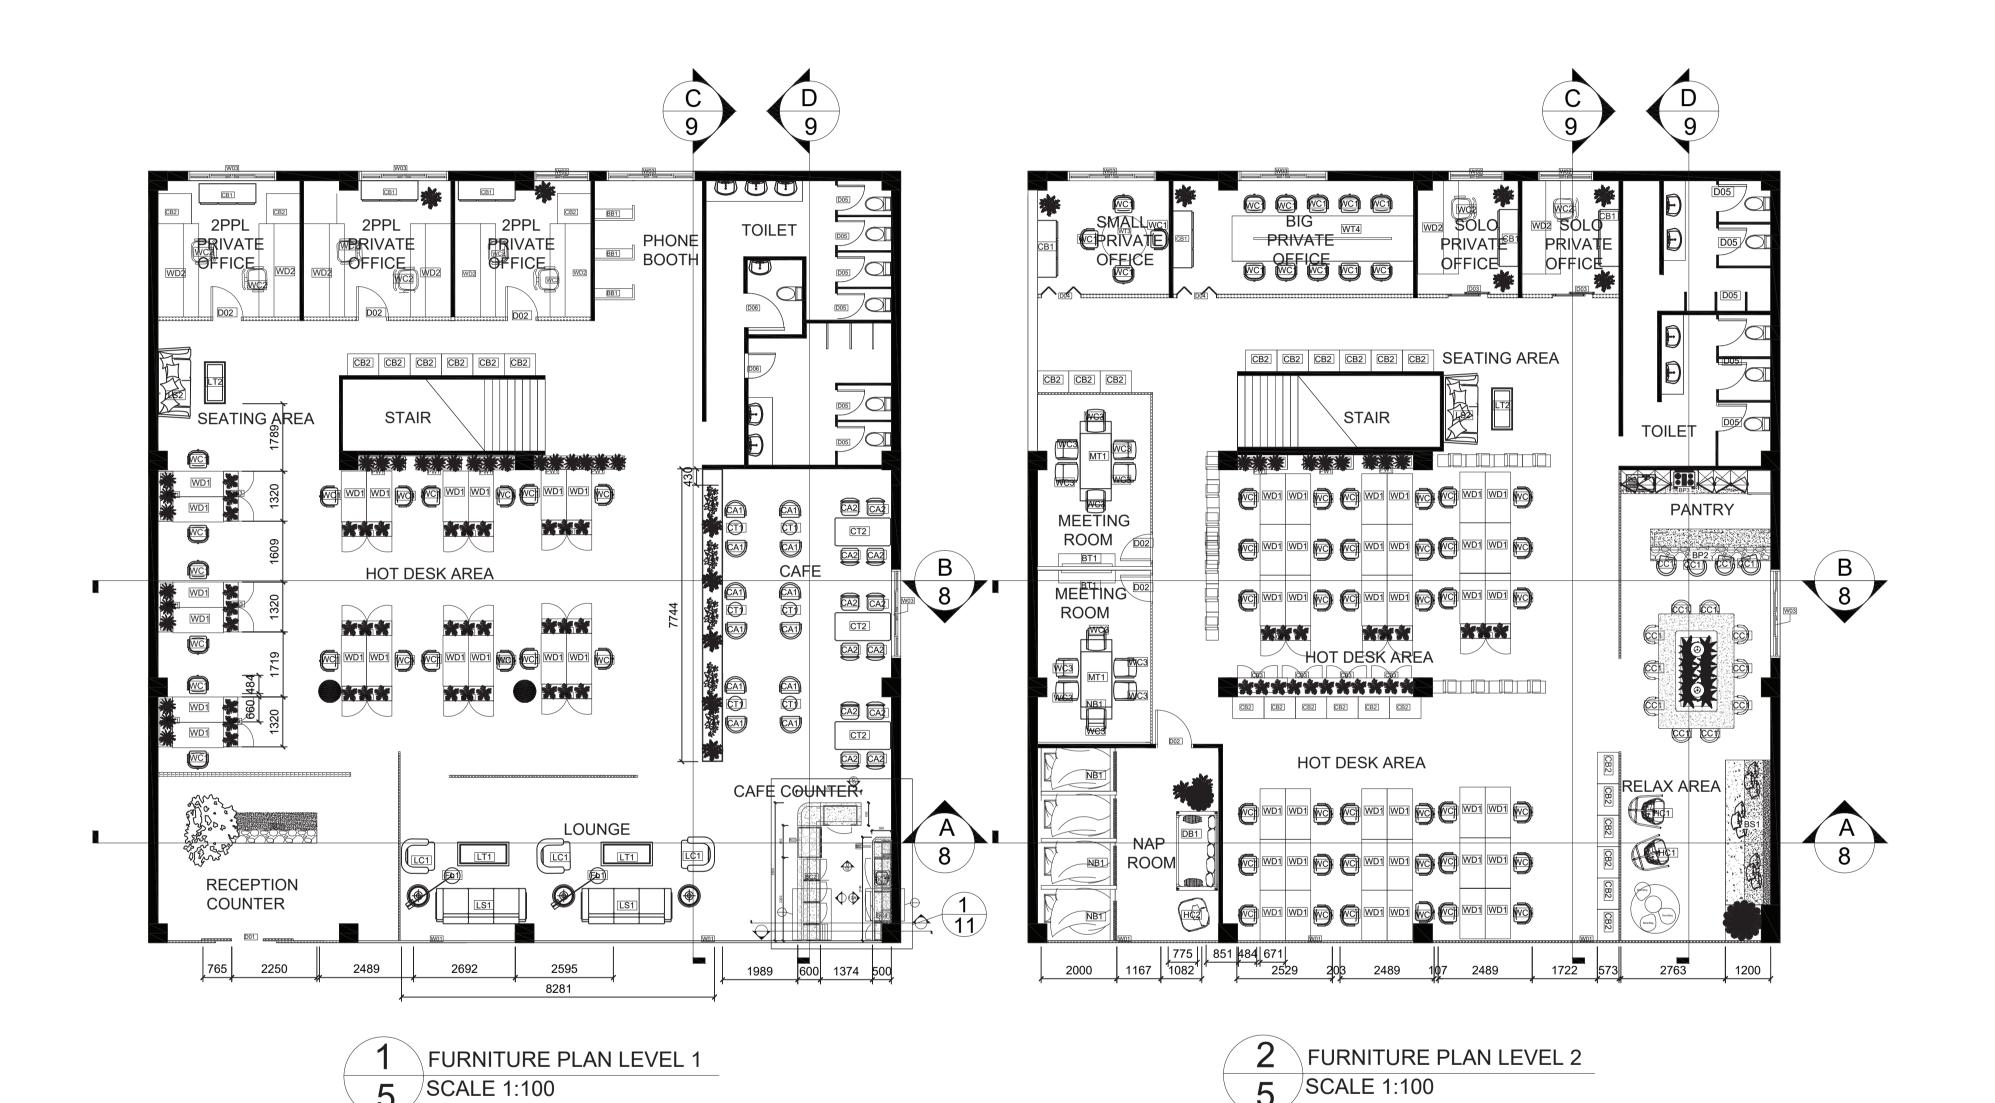

The contractor to be responsible for:

Verifying all drawings, specifications, dimensions and measurements as well as site, conditions and notifying the designer of all discrepancies and omissions before commencing the works.

Submitting samples and shop drawings for review and approval by designer before commencing works.

Ensuring that all work is keeping with all International building codes.

All necessary repairs, patching and cleaning of site during and after completition of works.

Verifying existing site conditions prior to

submissions of quotations.
Not starting the construction unless these drawings are signed approved.
All work specified on all drawings and specifications and supplying all necessary materials and labour required to complete all

phases of work in accordance with the designer's

standards.
- All dimensions in millimeters

SPECIFIC NOTES:

	FURNI	TURE	
CODE	DISCRIPTION	CODE	DISCRIPTION
WD1	WORKING DESK (HOT DESK AREA)	LC1	LOUNGE ARMCHAIR (LOUNGE AREA)
WC1	WORKING CHAIR (HOT DESK AREA)	BP2	BUILD IN ISLAND COUNTER (PANTRY)
WD2	WORKING DESK (PRIVATE OFFICE)	BP3	BUILD IN KITCHEN COUNTER (PANTRY)
WC2	WORKING CHAIR (PRIVATE OFFICE)	BT1	BUILD IN TV CABINET (METING ROOM)
MT1	MEETING TABLE	BC2	BUILD IN CASHIER CAFE COUNTER (CAFE)
WC3	WORKING CHAIR (MEETING ROOM)	ВС3	BUILD IN CAFE COUNTER (CAFE)
WT3	WORKING TABLE (SMALL PRIVATE OFFICE)	BC4	BUILD IN CAFE SHELVING(CAFE)
WT4	WORKING TABLE (BIG PRIVATE OFFICE)	СВЗ	CABINET WITH PLANT ON TOP
CA1	CAFE ARMCHAIR TYPE 1	FL1	FLOOR LAMP (LOUNGE)
CT1	CAFE TABLE TYPE 1	PW1	PLANT PARTITION WALL
CA2	CAFE ARMCHAIR TYPE 2	D01	MAIN GLASS SLIDING DOOR 2400mm
CT2	CAFE TABLE TYPE 2	D02	SWING DOOR WITH METAL FRAME 900mm
LT2	LOUNGE TABLE (SEATING AREA)	D03	SLIDING GLASS DOOR 1200mm
BC1	BUILD IN RECEPTION COUNTER	D04	FOLDING DOOR 1200mm
BP1	BUILD IN COUNTER (PANTRY)	D05	TOILET DOOR 900mm
BB1	BUILD IN PHONE BOOTH	D06	TOILET ENTRANCE DOOR 900mm
CC1	COUNTER CHAIR (PANTRY)	W01	GLASS WINDOW (FRONT BUILDING)
BS1	BUILD IN STAIR SEAT(PANTRY)	W02	2- GLASS WINDOW
HC1	HANGING CHAIR (PANTRY)	W03	3- GLASS WINDOW
HC2	HANGING CHAIR (NAP ROOM)		MACHINERY
DB1	DAY BED (NAP ROOM)	KC1	SMALL FRIDGE
NB1	NAP BED (NAP ROOM)	KC2	COFFEE MACHINE
CB1	CABINET	КС3	MOUNTED CUP DISPENSER
CB2	LOCKER	KC4	CASH MACHINE
LS1	LOUNGE SOFA (LOUNGE AREA)	KC5	CAKE MACHINE



NO. DATE: REVISIONS:

ASSIGNMENT TITLE: DOCUMENTATION PROJECT (FINAL)

DRAWING TITLE: FURNITURE PLAN

NAME: BUNHANGLINA YEA

COURSE: SYSTEM AND DOCUMENTATION 3

TERM: 1

ASSIGNMENT NO.:4


LECTURER : SOPHIE LUCAS

DATE: 9 MAY 2020

SHEET:

SCALE: 1:100

5

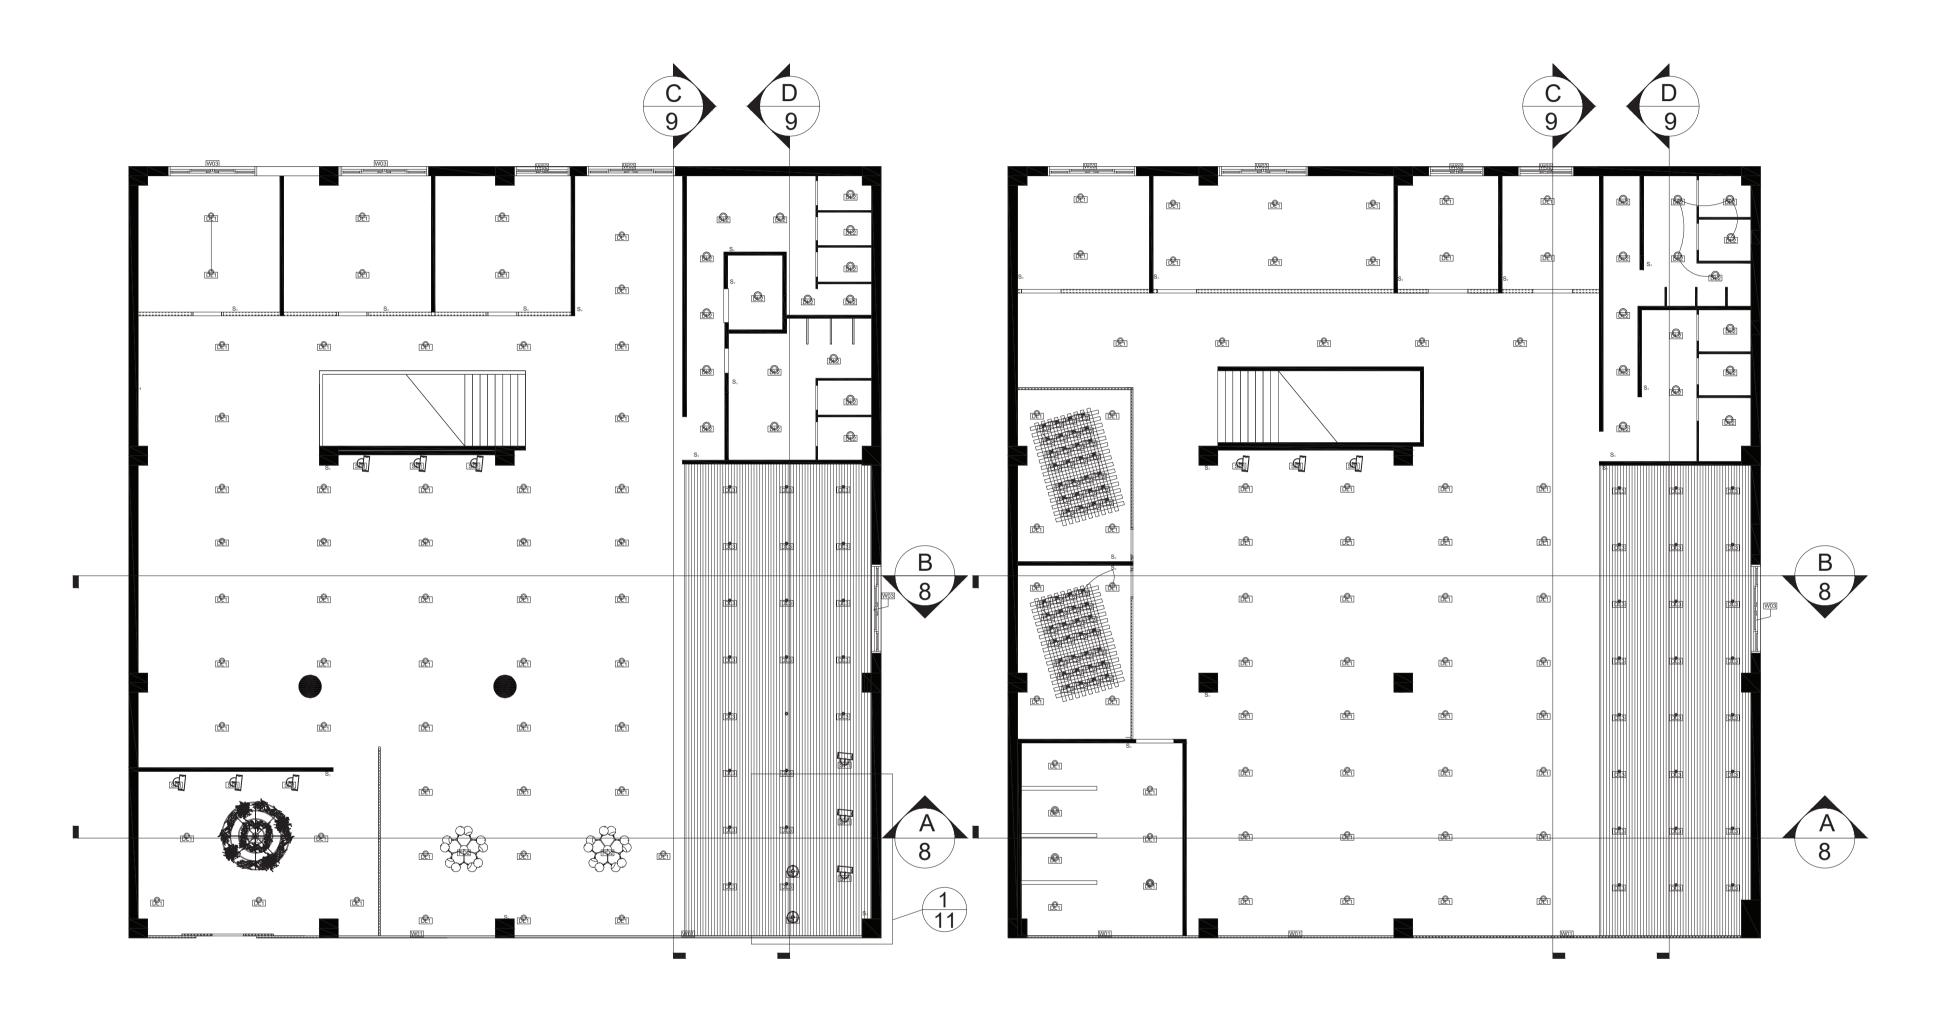

1 REFLECTED CEILING PLAN LEVEL 1
6 SCALE 1:100

2 REFLECTED CEILING PLAN LEVEL 2
6 SCALE 1:100

GENERAL NOTES

and measurements as well as site, conditions and notifying the designer of all discrepancies and omissions before commencing the works.
Submitting samples and shop drawings for review and approval by designer before commencing works.
Ensuring that all work is keeping with all International building codes.
All necessary repairs, patching and cleaning of site during and after completition of works.
Verifying existing site conditions prior to submissions of quotations.
Not starting the construction unless these drawings are signed approved.
All work specified on all drawings and

specifications and supplying all necessary materials and labour required to complete all

phases of work in accordance with the designer's

The contractor to be responsible for:

- Verifying all drawings, specifications, dimensions

- All dimensions in millimeters

SPECIFIC NOTES:

standards.

LIGHTING		
E DISCRIPTION		
SURFACE MOUNTED DOWN LIGHT W:157mm,H:85mm		
RECESS DOWN LIGHT		
SURFACE MOUNTED DOWN LIGHT W:85mm, H:190mm		
HANGING PLANTS PENDANT LIGHT		
GLOBE PENDANT LIGHT		
RAIN DROP PENDANT LIGHT		
BURTON LED SPOT LIGHT		
Contemporary Minimalist Metal Ring Globe Glass		
DUPLEX POWER RECEPTACE		
TELE/DATA OUTLET		
SMOKE ALARM		
CONDUIT CABLING		
LIGHTING FIXTURE WIRING		
SWITCH		
1		

NO. DATE: REVISIONS:

ASSIGNMENT TITLE: DOCUMENTATION PROJECT (FINAL)

DRAWING TITLE: REFLECTED CEILING PLAN

NAME: BUNHANGLINA YEA

COURSE: SYSTEM AND DOCUMENTATION 3

TERM: 1


ASSIGNMENT NO.:4


LECTURER : SOPHIE LUCAS

DATE: 9 MAY 2020

SCALE: 1:100

— (C

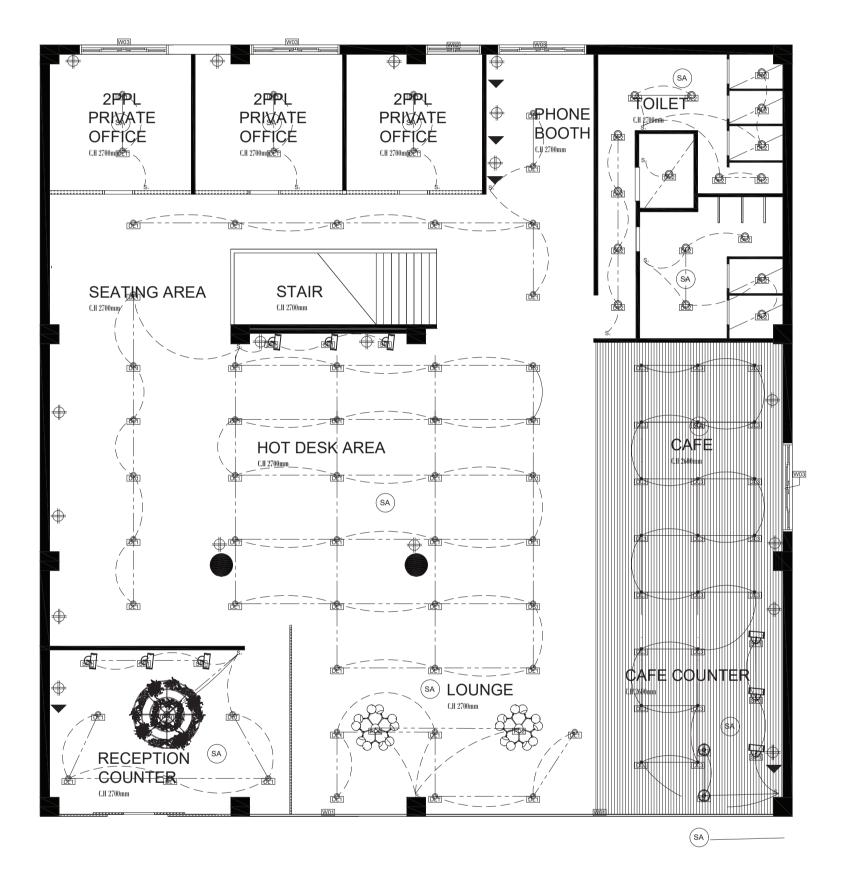

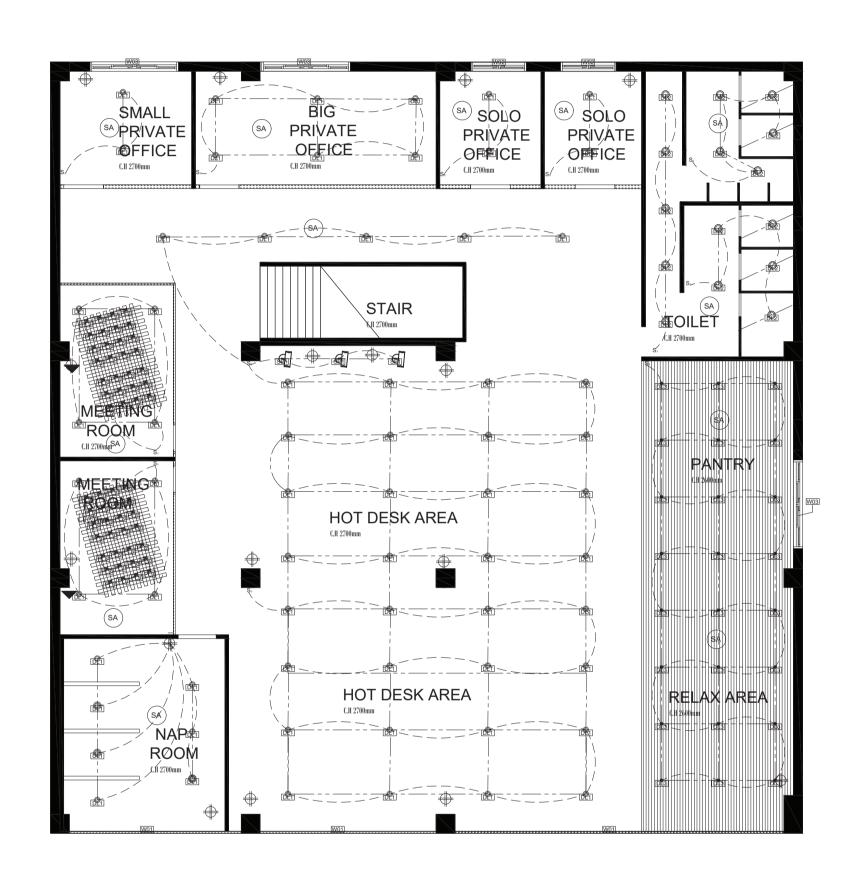

1 ELECTRICAL PLAN LEVEL 1
7 SCALE 1:100

2 ELECTRICAL PLAN LEVEL 2 7 SCALE 1:100

GENERAL NOTES

Verifying all drawings, specifications, dimensions and measurements as well as site, conditions and notifying the designer of all discrepancies and omissions before commencing the works.
Submitting samples and shop drawings for review and approval by designer before commencing works.
Ensuring that all work is keeping with all International building codes.
All necessary repairs, patching and cleaning of site during and after completition of works.
Verifying existing site conditions prior to submissions of quotations.
Not starting the construction unless these drawings are signed approved.

- All work specified on all drawings and specifications and supplying all necessary materials and labour required to complete all phases of work in accordance with the designer's

The contractor to be responsible for:

standards.
- All dimensions in millimeters

SPECIFIC NOTES:

LIGHTING		
CODE	DISCRIPTION	
© DL1	SURFACE MOUNTED DOWN LIGHT W:157mm,H:85mm	
O DL2	RECESS DOWN LIGHT	
© DL3	SURFACE MOUNTED DOWN LIGHT W:85mm, H:190mm	
PL1	HANGING PLANTS PENDANT LIGHT	
2558 PL2	GLOBE PENDANT LIGHT	
⊚ PL3	RAIN DROP PENDANT LIGHT	
∯] SP1	BURTON LED SPOT LIGHT	
GL ₁	Contemporary Minimalist Metal Ring Globe Glass	
	DUPLEX POWER RECEPTACE	
	TELE/DATA OUTLET	
SA	SMOKE ALARM	
	CONDUIT CABLING	
	LIGHTING FIXTURE WIRING	
S ₂	SWITCH	



NO. DATE: REVISIONS:

ASSIGNMENT TITLE: DOCUMENTATION PROJECT (FINAL)

DRAWING TITLE: ELECTRICAL PLAN

NAME: BUNHANGLINA YEA

COURSE: SYSTEM AND DOCUMENTATION 3

TERM: 1


ASSIGNMENT NO.:4

LECTURER : SOPHIE LUCAS

DATE: 9 MAY 2020

SHEET:

SCALE: 1:100

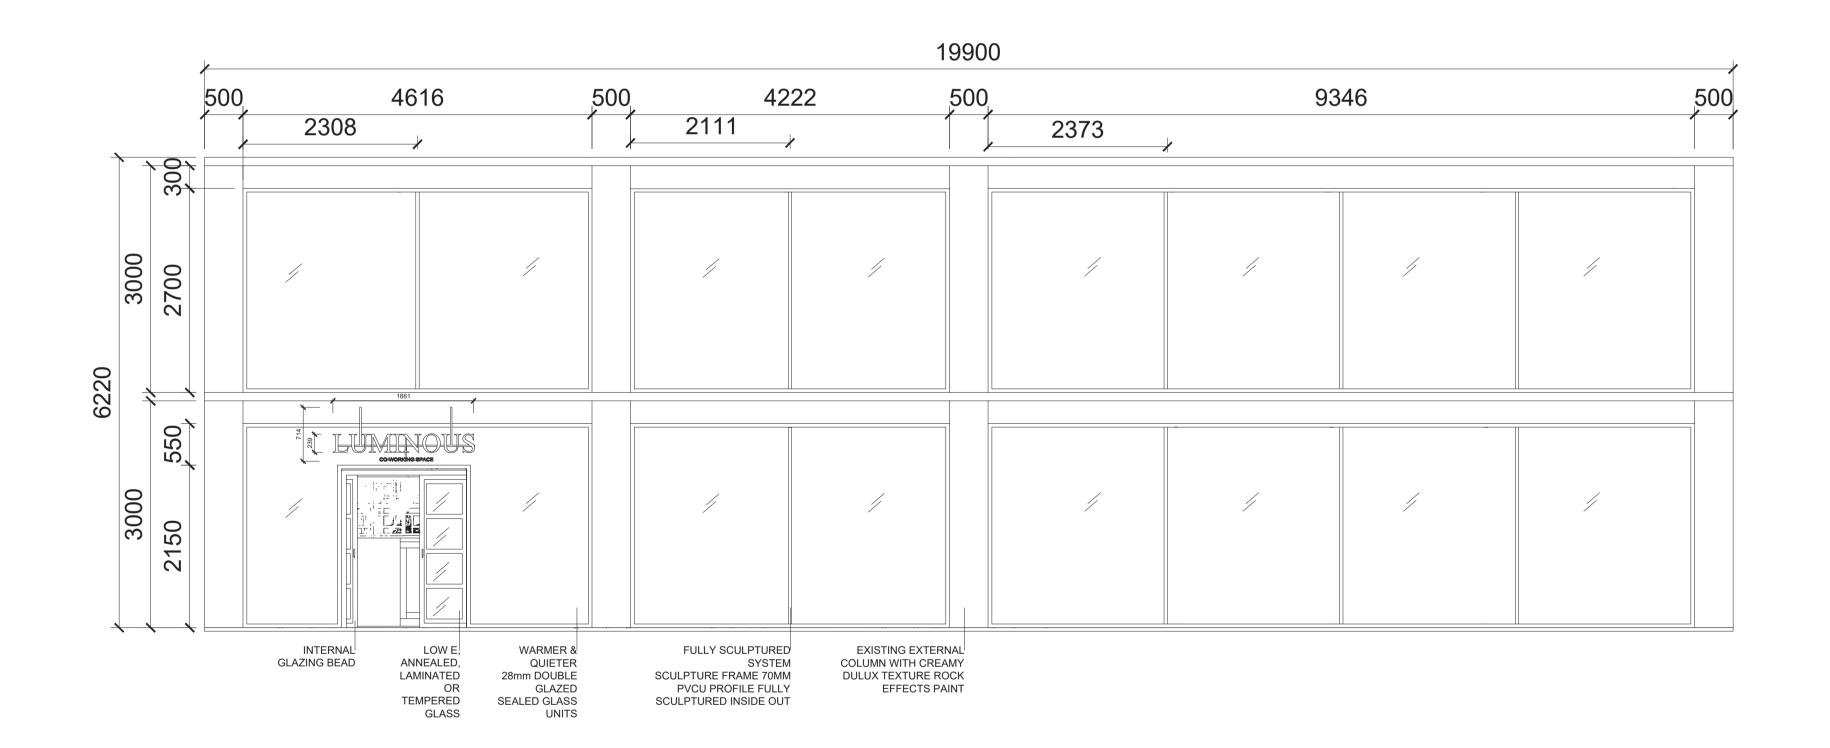



The contractor to be responsible for:
Verifying all drawings, specifications, dimensions and measurements as well as site, conditions and notifying the designer of all discrepancies and omissions before commencing the works.
Submitting samples and shop drawings for review and approval by designer before commencing works.
Ensuring that all work is keeping with all International building codes.
All necessary repairs, patching and cleaning of site during and after completition of works.
Verifying existing site conditions prior to submissions of quotations.
Not starting the construction unless these drawings are signed approved.
All work specified on all drawings and

specifications and supplying all necessary materials and labour required to complete all

phases of work in accordance with the designer's

standards.
- All dimensions in millimeters

SPECIFIC NOTES:

	FURNITURE			
CODE	DISCRIPTION	CODE	DISCRIPTION	
WD1	WORKING DESK (HOT DESK AREA)	LC1	LOUNGE ARMCHAIR (LOUNGE AR	
WC1	WORKING CHAIR (HOT DESK AREA)	BP2	BUILD IN ISLAND COUNTER (PANT	
WD2	WORKING DESK (PRIVATE OFFICE)	BP3	BUILD IN KITCHEN COUNTER (PA	
WC2	WORKING CHAIR (PRIVATE OFFICE)	BT1	BUILD IN TV CABINET (METING RO	
MT1	MEETING TABLE	BC2	BUILD IN CASHIER CAFE COUNTE CAFE)	
WC3	WORKING CHAIR (MEETING ROOM)	ВС3	BUILD IN CAFE COUNTER (CAFE)	
WT3	WORKING TABLE (SMALL PRIVATE OFFICE)	BC4	BUILD IN CAFE SHELVING(CAFE)	
WT4	WORKING TABLE (BIG PRIVATE OFFICE)	CB3	CABINET WITH PLANT ON TOP	
CA1	CAFE ARMCHAIR TYPE 1	FL1	FLOOR LAMP (LOUNGE)	
CT1	CAFE TABLE TYPE 1	PW1	PLANT PARTITION WALL	
CA2	CAFE ARMCHAIR TYPE 2	D01	MAIN GLASS SLIDING DOOR 2400m	
CT2	CAFE TABLE TYPE 2	D02	SWING DOOR WITH METAL FRAME 900mm	
LT2	LOUNGE TABLE (SEATING AREA)	D03	SLIDING GLASS DOOR 1200mm	
BC1	BUILD IN RECEPTION COUNTER	D04	FOLDING DOOR 1200mm	
BP1	BUILD IN COUNTER (PANTRY)	D05	TOILET DOOR 900mm	
BB1	BUILD IN PHONE BOOTH	D06	TOILET ENTRANCE DOOR 900mm	
CC1	COUNTER CHAIR (PANTRY)	W01	GLASS WINDOW (FRONT BUILDIN	
BS1	BUILD IN STAIR SEAT(PANTRY)	W02	2- GLASS WINDOW	
HC1	HANGING CHAIR (PANTRY)	W03	3- GLASS WINDOW	
HC2	HANGING CHAIR (NAP ROOM)		MACHINERY	
DB1	DAY BED (NAP ROOM)	KC1	SMALL FRIDGE	
NB1	NAP BED (NAP ROOM)	KC2	COFFEE MACHINE	
CB1	CABINET	KC3	MOUNTED CUP DISPENSER	
CB2	LOCKER	KC4	CASH MACHINE	



NO. DATE: REVISIONS:

ASSIGNMENT TITLE: DOCUMENTATION PROJECT (FINAL)

DRAWING TITLE: EXTERNAL ELEVATION

NAME: BUNHANGLINA YEA

COURSE: SYSTEM AND DOCUMENTATION 3

TERM: 1

ASSIGNMENT NO.:4


LECTURER : SOPHIE LUCAS


DATE: 9 MAY 2020

 
SHEET:

SCALE: 1:100

8

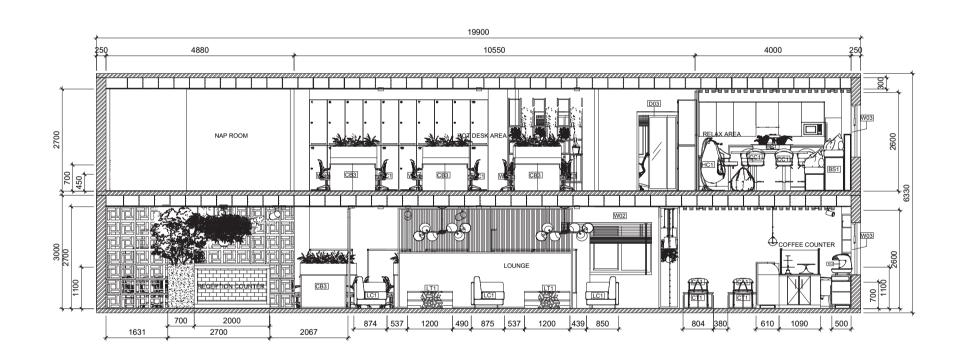

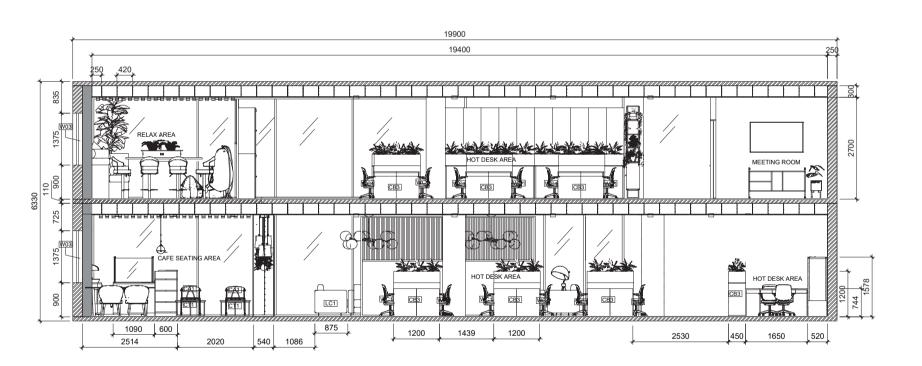





and measurements as well as site, conditions and notifying the designer of all discrepancies and omissions before commencing the works.
Submitting samples and shop drawings for review and approval by designer before commencing works.
Ensuring that all work is keeping with all International building codes.
All necessary repairs, patching and cleaning of site during and after completition of works.
Verifying existing site conditions prior to submissions of quotations.
Not starting the construction unless these drawings are signed approved.
All work specified on all drawings and specifications and supplying all necessary materials and labour required to complete all

phases of work in accordance with the designer's

The contractor to be responsible for:

- Verifying all drawings, specifications,dimensions

SPECIFIC NOTES:

- All dimensions in millimeters

standards.

	FURNI	TURE	
CODE	DISCRIPTION	CODE	DISCRIPTION
WD1	WORKING DESK (HOT DESK AREA)	LC1	LOUNGE ARMCHAIR (LOUNGE AREA)
WC1	WORKING CHAIR (HOT DESK AREA)	BP2	BUILD IN ISLAND COUNTER (PANTRY)
WD2	WORKING DESK (PRIVATE OFFICE)	BP3	BUILD IN KITCHEN COUNTER (PANTR
WC2	WORKING CHAIR (PRIVATE OFFICE)	BT1	BUILD IN TV CABINET (METING ROOM
MT1	MEETING TABLE	BC2	BUILD IN CASHIER CAFE COUNTER (CAFE)
WC3	WORKING CHAIR (MEETING ROOM)	вс3	BUILD IN CAFE COUNTER (CAFE)
WT3	WORKING TABLE (SMALL PRIVATE OFFICE)	BC4	BUILD IN CAFE SHELVING(CAFE)
WT4	WORKING TABLE (BIG PRIVATE OFFICE)	СВЗ	CABINET WITH PLANT ON TOP
CA1	CAFE ARMCHAIR TYPE 1	FL1	FLOOR LAMP (LOUNGE)
CT1	CAFE TABLE TYPE 1	PW1	PLANT PARTITION WALL
CA2	CAFE ARMCHAIR TYPE 2	D01	MAIN GLASS SLIDING DOOR 2400mm
CT2	CAFE TABLE TYPE 2	D02	SWING DOOR WITH METAL FRAME 900mm
LT2	LOUNGE TABLE (SEATING AREA)	D03	SLIDING GLASS DOOR 1200mm
BC1	BUILD IN RECEPTION COUNTER	D04	FOLDING DOOR 1200mm
BP1	BUILD IN COUNTER (PANTRY)	D05	TOILET DOOR 900mm
BB1	BUILD IN PHONE BOOTH	D06	TOILET ENTRANCE DOOR 900mm
CC1	COUNTER CHAIR (PANTRY)	W01	GLASS WINDOW (FRONT BUILDING)
BS1	BUILD IN STAIR SEAT(PANTRY)	W02	2- GLASS WINDOW
HC1	HANGING CHAIR (PANTRY)	W03	3- GLASS WINDOW
HC2	HANGING CHAIR (NAP ROOM)		MATERIAL
DB1	DAY BED (NAP ROOM)	SC1	WHITE GLOSSY FINISH CERAMIC TILE BACKSPLASH
NB1	NAP BED (NAP ROOM)	MC1	20mm BLACK MARBLE TOP
CB1	CABINET	MC2	20mm MDF BOARD WITH GRAY WOOD LAMINATE ON TOP
CB2	LOCKER	MC3	METAL CABINET HANDLE
LS1	LOUNGE SOFA (LOUNGE AREA)	MC4	MDF BOARD TOEKICK WITH METAL SHEET FINSIHES
	MACHINERY	MC5	15mm BLACK CHOCK BOARD
KC1	SMALL FRIDGE	MC6	5mm TRANSPARENT GLASS
KC2	COFFEE MACHINE	MC7	10MM MDF SHELVE BAORD
КС3	MOUNTED CUP DISPENSER	MC8	90X45mm SUPPORTING TIMBER BLOC
KC5	CAKE MACHINE	MC9	W: 8mm, L:100, H: 1000mm, VERTICAL WOOD PANEL



NO. DATE: REVISIONS:

ASSIGNMENT TITLE: DOCUMENTATION PROJECT (FINAL)

DRAWING TITLE: SECTION A & SECTION B

NAME: BUNHANGLINA YEA

COURSE: SYSTEM AND DOCUMENTATION 3

TERM: 1


ASSIGNMENT NO.:4


LECTURER : SOPHIE LUCAS

DATE: 9 MAY 2020

SCALE: 1:100



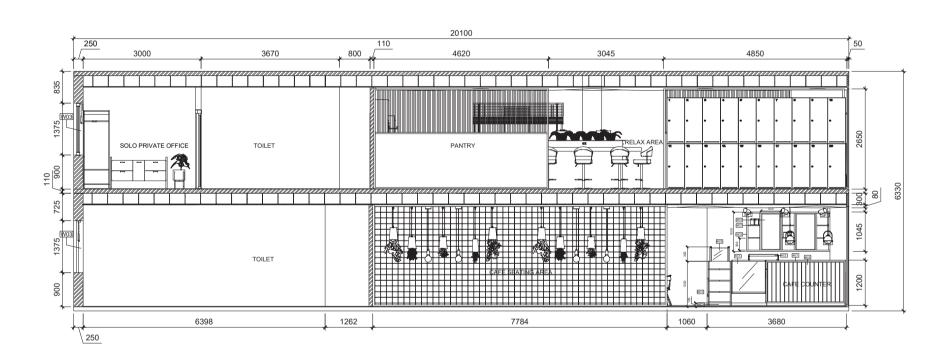

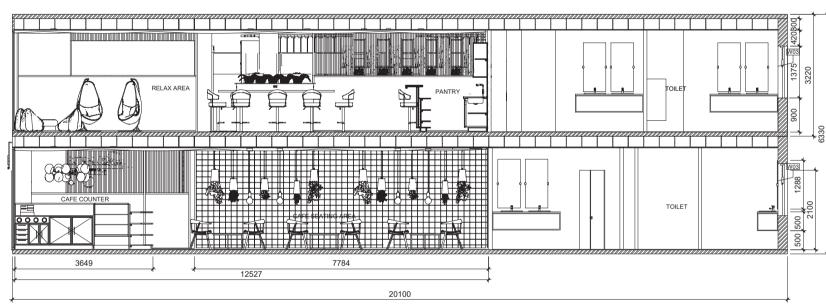

D SECTION D SCALE 1:100

GENERAL NOTES

The contractor to be responsible for: - Verifying all drawings, specifications,dimensions and measurements as well as site, conditions and notifying the designer of all discrepancies and omissions before commencing the works. - Submitting samples and shop drawings for review and approval by designer before commencing works. - Ensuring that all work is keeping with all International building codes. - All necessary repairs, patching and cleaning of site during and after completition of works. - Verifying existing site conditions prior to submissions of quotations. - Not starting the construction unless these drawings are signed approved. - All work specified on all drawings and specifications and supplying all necessary materials and labour required to complete all phases of work in accordance with the designer's

- All dimensions in millimeters

standards.

SPECIFIC NOTES:

	FURNI	TURE	
CODE	DISCRIPTION	CODE	DISCRIPTION
WD1	WORKING DESK (HOT DESK AREA)	LC1	LOUNGE ARMCHAIR (LOUNGE AREA)
WC1	WORKING CHAIR (HOT DESK AREA)	BP2	BUILD IN ISLAND COUNTER (PANTRY
WD2	WORKING DESK (PRIVATE OFFICE)	BP3	BUILD IN KITCHEN COUNTER (PANTR
WC2	WORKING CHAIR (PRIVATE OFFICE)	BT1	BUILD IN TV CABINET (METING ROOM
MT1	MEETING TABLE	BC2	BUILD IN CASHIER CAFE COUNTER (CAFE)
WC3	WORKING CHAIR (MEETING ROOM)	вс3	BUILD IN CAFE COUNTER (CAFE)
WT3	WORKING TABLE (SMALL PRIVATE OFFICE)	BC4	BUILD IN CAFE SHELVING(CAFE)
WT4	WORKING TABLE (BIG PRIVATE OFFICE)	СВЗ	CABINET WITH PLANT ON TOP
CA1	CAFE ARMCHAIR TYPE 1	FL1	FLOOR LAMP (LOUNGE)
CT1	CAFE TABLE TYPE 1	PW1	PLANT PARTITION WALL
CA2	CAFE ARMCHAIR TYPE 2	D01	MAIN GLASS SLIDING DOOR 2400mm
CT2	CAFE TABLE TYPE 2	D02	SWING DOOR WITH METAL FRAME 900mm
LT2	LOUNGE TABLE (SEATING AREA)	D03	SLIDING GLASS DOOR 1200mm
BC1	BUILD IN RECEPTION COUNTER	D04	FOLDING DOOR 1200mm
BP1	BUILD IN COUNTER (PANTRY)	D05	TOILET DOOR 900mm
BB1	BUILD IN PHONE BOOTH	D06	TOILET ENTRANCE DOOR 900mm
CC1	COUNTER CHAIR (PANTRY)	W01	GLASS WINDOW (FRONT BUILDING)
BS1	BUILD IN STAIR SEAT(PANTRY)	W02	2- GLASS WINDOW
HC1	HANGING CHAIR (PANTRY)	W03	3- GLASS WINDOW
HC2	HANGING CHAIR (NAP ROOM)		MATERIAL
DB1	DAY BED (NAP ROOM)	SC1	WHITE GLOSSY FINISH CERAMIC TILE BACKSPLASH
NB1	NAP BED (NAP ROOM)	MC1	20mm BLACK MARBLE TOP
CB1	CABINET	MC2	20mm MDF BOARD WITH GRAY WOOL LAMINATE ON TOP
CB2	LOCKER	MC3	METAL CABINET HANDLE
LS1	LOUNGE SOFA (LOUNGE AREA)	MC4	MDF BOARD TOEKICK WITH METAL SHEET FINSIHES
	MACHINERY	MC5	15mm BLACK CHOCK BOARD
KC1	SMALL FRIDGE	MC6	5mm TRANSPARENT GLASS
KC2	COFFEE MACHINE	MC7	10MM MDF SHELVE BAORD
КС3	MOUNTED CUP DISPENSER	MC8	90X45mm SUPPORTING TIMBER BLOC
KC5	CAKE MACHINE	MC9	W: 8mm, L:100, H: 1000mm, VERTICAL WOOD PANEL



NO. DATE: REVISIONS:

ASSIGNMENT TITLE: DOCUMENTATION PROJECT (FINAL)

DRAWING TITLE: SECTION C & SECTION D

NAME: BUNHANGLINA YEA

COURSE: SYSTEM AND DOCUMENTATION 3


TERM: 1

ASSIGNMENT NO.:4

LECTURER: SOPHIE LUCAS

DATE: 9 MAY 2020

SCALE: 1:100

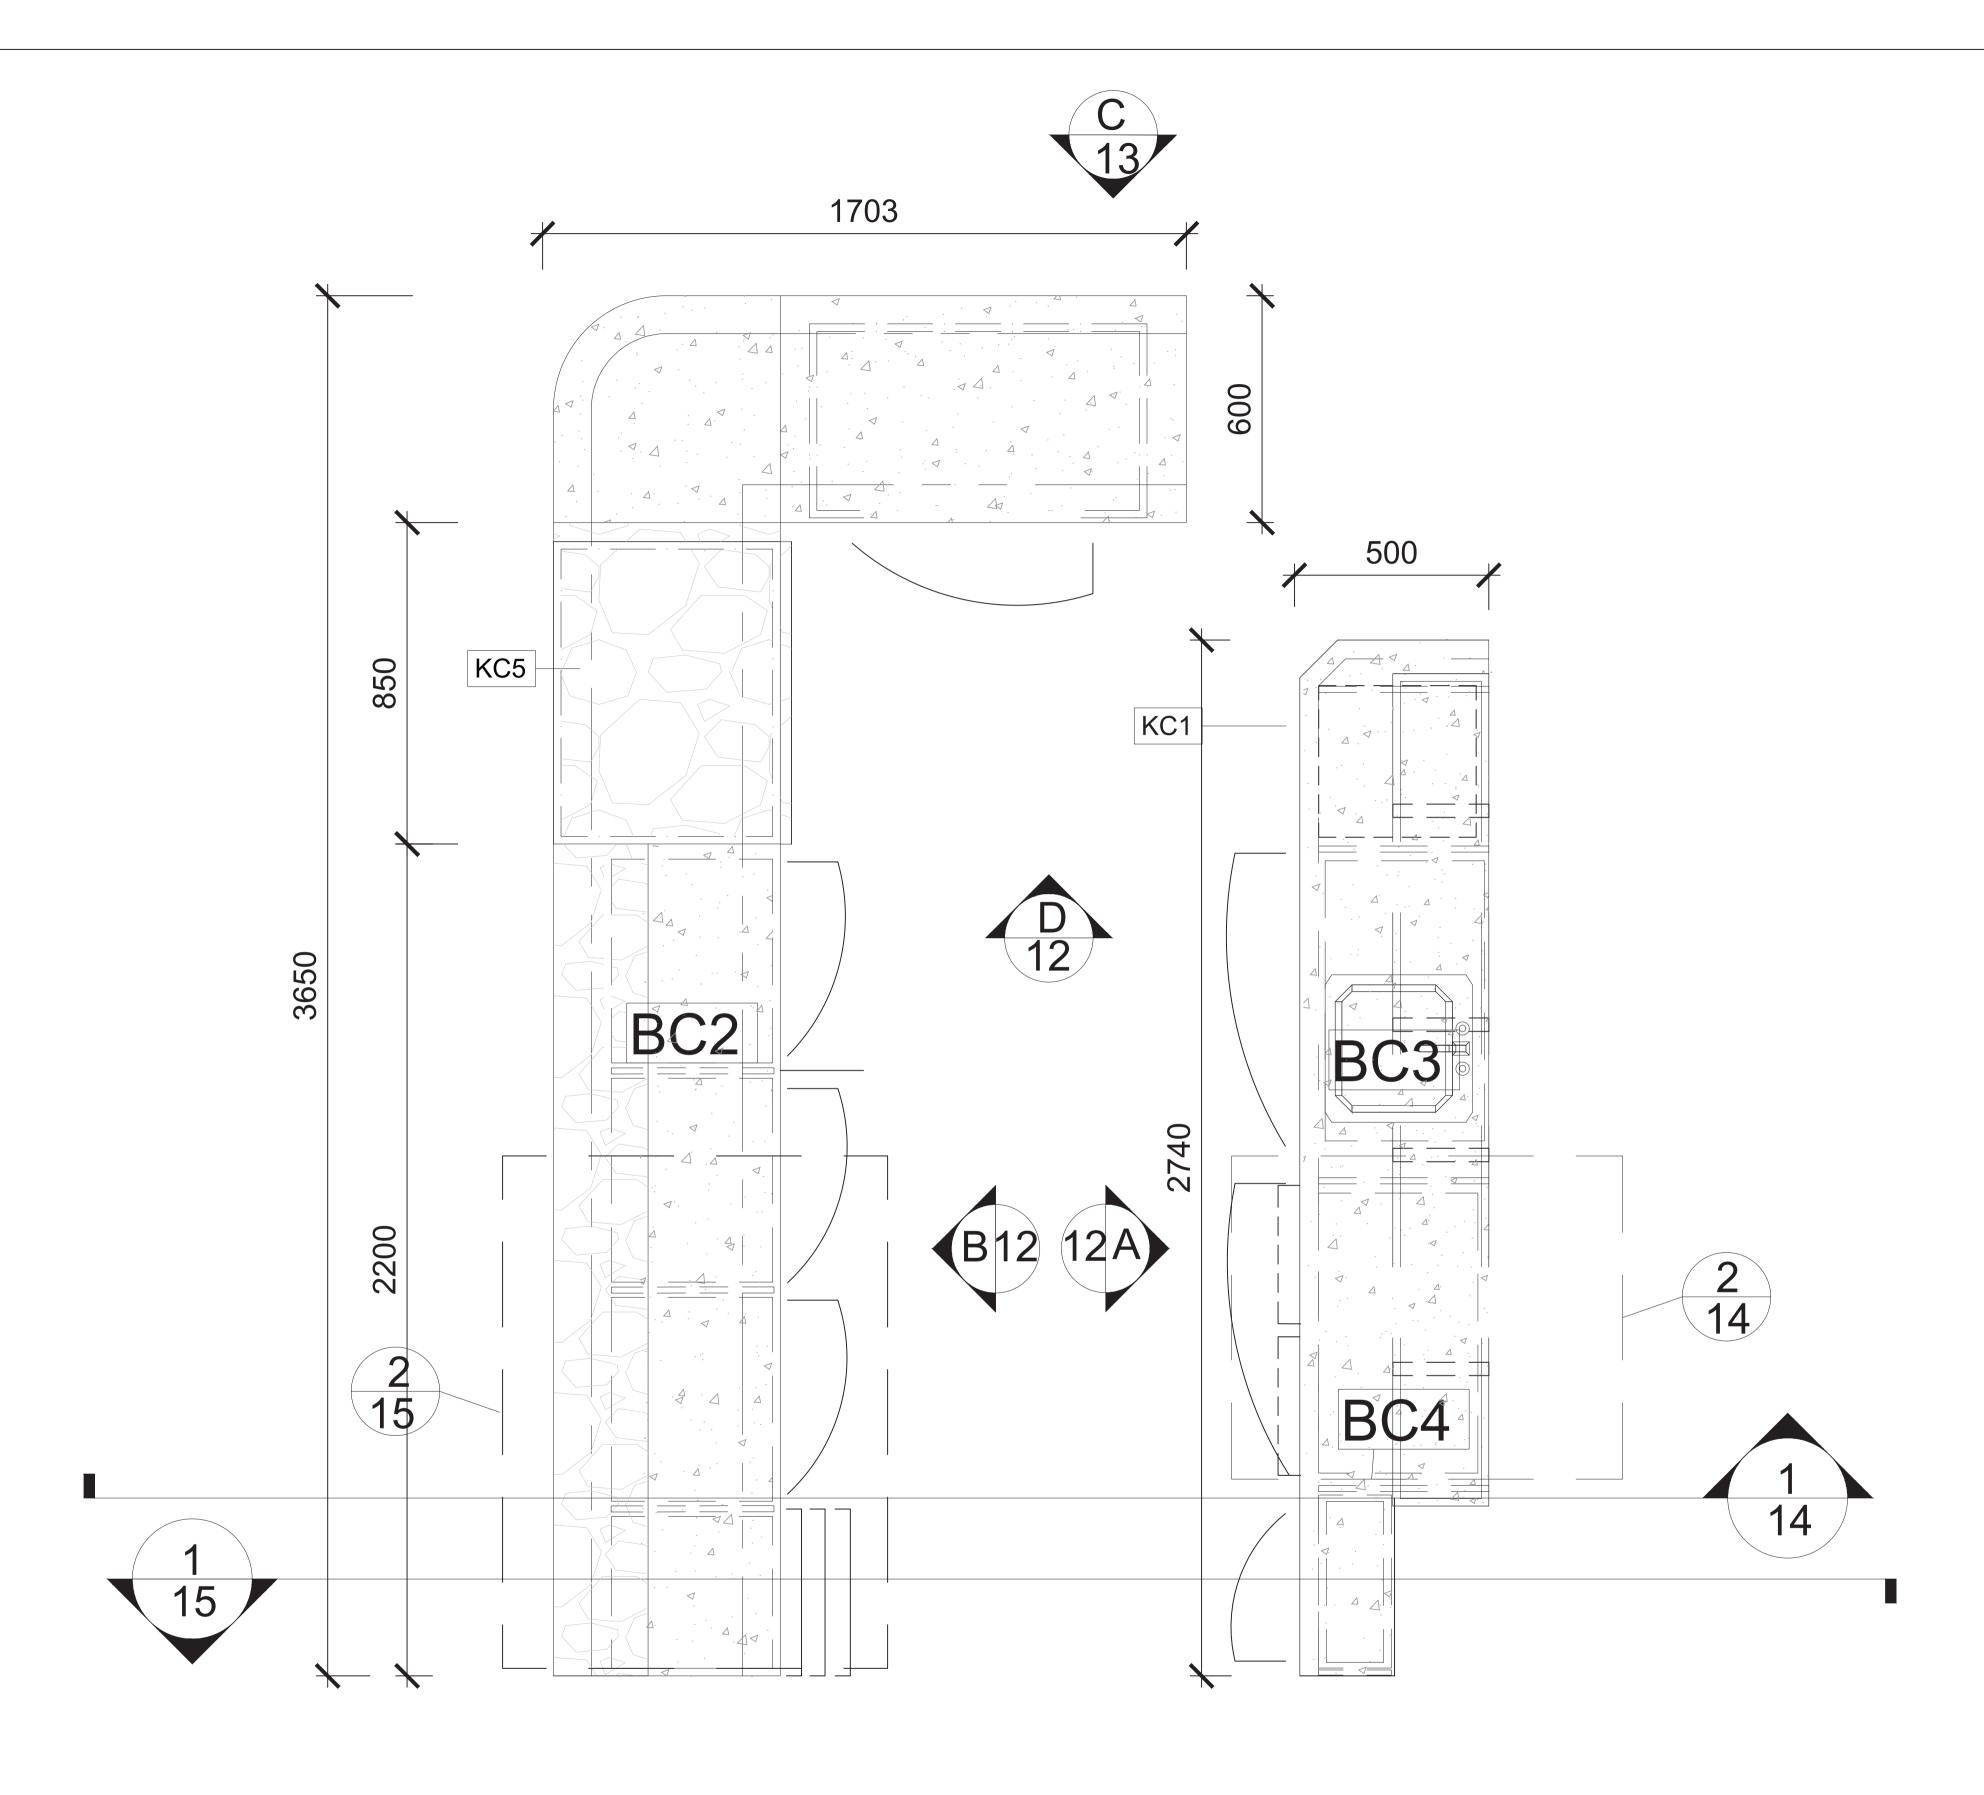

1 CAFE COUNTER INTERNAL PLAN
11 SCALE 1:10

GENERAL NOTES

The contractor to be responsible for:
Verifying all drawings, specifications, dimensions and measurements as well as site, conditions and notifying the designer of all discrepancies and omissions before commencing the works.
Submitting samples and shop drawings for review and approval by designer before commencing works.
Ensuring that all work is keeping with all International building codes.

International building codes.
All necessary repairs, patching and cleaning of site during and after completition of works.
Verifying existing site conditions prior to submissions of quotations.

Not starting the construction unless these drawings are signed approved.
All work specified on all drawings and specifications and supplying all necessary materials and labour required to complete all phases of work in accordance with the designer's

- All dimensions in millimeters

standards.

SPECIFIC NOTES:

	FURNI	TURE	
CODE	DISCRIPTION	CODE	DISCRIPTION
WD1	WORKING DESK (HOT DESK AREA)	LC1	LOUNGE ARMCHAIR (LOUNGE ARE
WC1	WORKING CHAIR (HOT DESK AREA)	BP2	BUILD IN ISLAND COUNTER (PANTE
WD2	WORKING DESK (PRIVATE OFFICE)	BP3	BUILD IN KITCHEN COUNTER (PAN
WC2	WORKING CHAIR (PRIVATE OFFICE)	BT1	BUILD IN TV CABINET (METING ROO
MT1	MEETING TABLE	BC2	BUILD IN CASHIER CAFE COUNTER CAFE)
WC3	WORKING CHAIR (MEETING ROOM)	вс3	BUILD IN CAFE COUNTER (CAFE)
WT3	WORKING TABLE (SMALL PRIVATE OFFICE)	BC4	BUILD IN CAFE SHELVING(CAFE)
WT4	WORKING TABLE (BIG PRIVATE OFFICE)	CB3	CABINET WITH PLANT ON TOP
CA1	CAFE ARMCHAIR TYPE 1	FL1	FLOOR LAMP (LOUNGE)
CT1	CAFE TABLE TYPE 1	PW1	PLANT PARTITION WALL
CA2	CAFE ARMCHAIR TYPE 2	D01	MAIN GLASS SLIDING DOOR 2400mm
CT2	CAFE TABLE TYPE 2	D02	SWING DOOR WITH METAL FRAME 900mm
LT2	LOUNGE TABLE (SEATING AREA)	D03	SLIDING GLASS DOOR 1200mm
BC1	BUILD IN RECEPTION COUNTER	D04	FOLDING DOOR 1200mm
BP1	BUILD IN COUNTER (PANTRY)	D05	TOILET DOOR 900mm
BB1	BUILD IN PHONE BOOTH	D06	TOILET ENTRANCE DOOR 900mm
CC1	COUNTER CHAIR (PANTRY)	W01	GLASS WINDOW (FRONT BUILDING
BS1	BUILD IN STAIR SEAT(PANTRY)	W02	2- GLASS WINDOW
HC1	HANGING CHAIR (PANTRY)	W03	3- GLASS WINDOW
HC2	HANGING CHAIR (NAP ROOM)		MATERIAL
DB1	DAY BED (NAP ROOM)	SC1	WHITE GLOSSY FINISH CERAMIC TI BACKSPLASH
NB1	NAP BED (NAP ROOM)	MC1	20mm BLACK MARBLE TOP
CB1	CABINET	MC2	20mm MDF BOARD WITH GRAY WOLLAMINATE ON TOP
CB2	LOCKER	MC3	METAL CABINET HANDLE
LS1	LOUNGE SOFA (LOUNGE AREA)	MC4	MDF BOARD TOEKICK WITH METAL SHEET FINSIHES
	MACHINERY	MC5	15mm BLACK CHOCK BOARD
KC1	SMALL FRIDGE	MC6	5mm TRANSPARENT GLASS
KC2	COFFEE MACHINE	MC7	10MM MDF SHELVE BAORD
KC3	MOUNTED CUP DISPENSER	MC8	90X45mm SUPPORTING TIMBER BL
KC5	CAKE MACHINE	MC9	W: 8mm, L:100, H: 1000mm, VERTICA WOOD PANEL



NO. DATE: REVISIONS:

ASSIGNMENT TITLE: DOCUMENTATION PROJECT (FINAL)

DRAWING TITLE: INTERNAL PLAN OF CAFE COUNTER

NAME: BUNHANGLINA YEA

COURSE: SYSTEM AND DOCUMENTATION 3


TERM: 1

ASSIGNMENT NO.:4

LECTURER : SOPHIE LUCAS

DATE: 9 MAY 2020

SCALE: 1:10

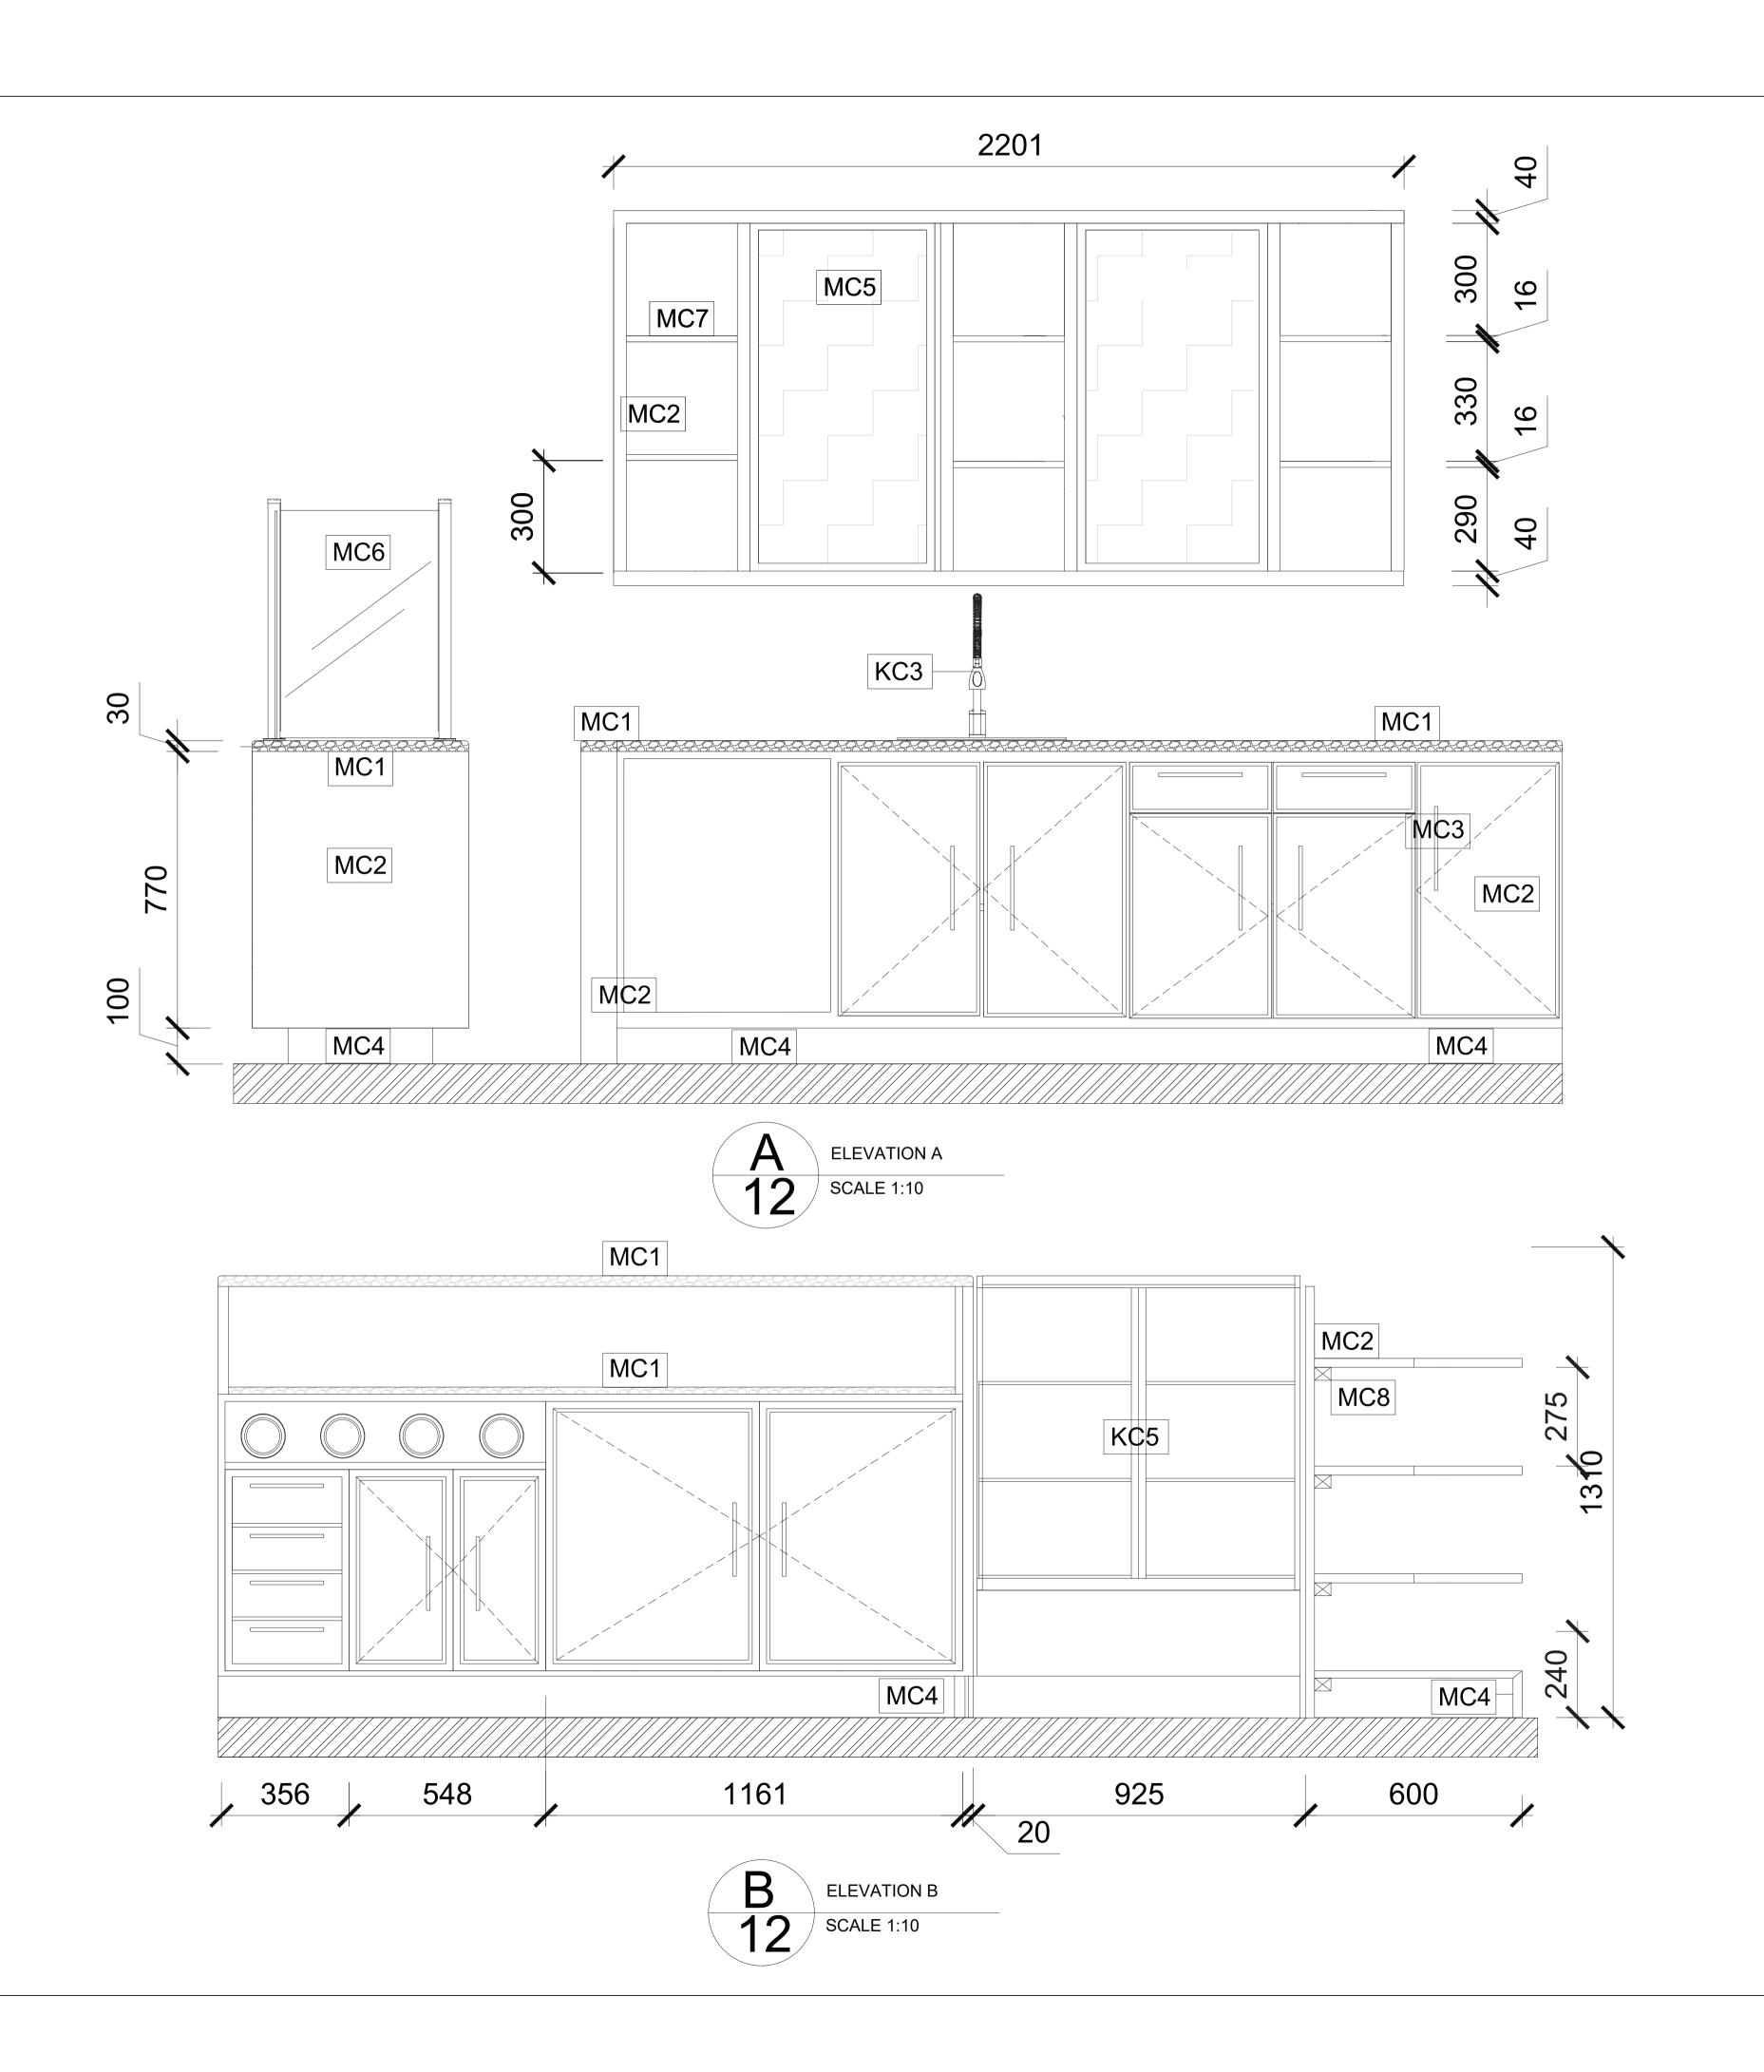

The contractor to be responsible for:
Verifying all drawings, specifications, dimensions and measurements as well as site, conditions and notifying the designer of all discrepancies and omissions before commencing the works.
Submitting samples and shop drawings for review and approval by designer before commencing works.
Ensuring that all work is keeping with all International building codes.

International building codes.
All necessary repairs, patching and cleaning of site during and after completition of works.
Verifying existing site conditions prior to submissions of quotations.

Not starting the construction unless these drawings are signed approved.
All work specified on all drawings and specifications and supplying all necessary materials and labour required to complete all phases of work in accordance with the designer's standards.

- All dimensions in millimeters

SPECIFIC NOTES:

	FURNI	TURE	
CODE	DISCRIPTION	CODE	DISCRIPTION
WD1	WORKING DESK (HOT DESK AREA)	LC1	LOUNGE ARMCHAIR (LOUNGE ARE
WC1	WORKING CHAIR (HOT DESK AREA)	BP2	BUILD IN ISLAND COUNTER (PANT
WD2	WORKING DESK (PRIVATE OFFICE)	BP3	BUILD IN KITCHEN COUNTER (PAI
WC2	WORKING CHAIR (PRIVATE OFFICE)	BT1	BUILD IN TV CABINET (METING RO
MT1	MEETING TABLE	BC2	BUILD IN CASHIER CAFE COUNTED
WC3	WORKING CHAIR (MEETING ROOM)	вс3	BUILD IN CAFE COUNTER (CAFE)
WT3	WORKING TABLE (SMALL PRIVATE OFFICE)	BC4	BUILD IN CAFE SHELVING(CAFE)
WT4	WORKING TABLE (BIG PRIVATE OFFICE)	СВЗ	CABINET WITH PLANT ON TOP
CA1	CAFE ARMCHAIR TYPE 1	FL1	FLOOR LAMP (LOUNGE)
CT1	CAFE TABLE TYPE 1	PW1	PLANT PARTITION WALL
CA2	CAFE ARMCHAIR TYPE 2	D01	MAIN GLASS SLIDING DOOR 2400m
CT2	CAFE TABLE TYPE 2	D02	SWING DOOR WITH METAL FRAME 900mm
LT2	LOUNGE TABLE (SEATING AREA)	D03	SLIDING GLASS DOOR 1200mm
BC1	BUILD IN RECEPTION COUNTER	D04	FOLDING DOOR 1200mm
BP1	BUILD IN COUNTER (PANTRY)	D05	TOILET DOOR 900mm
BB1	BUILD IN PHONE BOOTH	D06	TOILET ENTRANCE DOOR 900mm
CC1	COUNTER CHAIR (PANTRY)	W01	GLASS WINDOW (FRONT BUILDING
BS1	BUILD IN STAIR SEAT(PANTRY)	W02	2- GLASS WINDOW
HC1	HANGING CHAIR (PANTRY)	W03	3- GLASS WINDOW
HC2	HANGING CHAIR (NAP ROOM)		MATERIAL
DB1	DAY BED (NAP ROOM)	SC1	WHITE GLOSSY FINISH CERAMIC BACKSPLASH
NB1	NAP BED (NAP ROOM)	MC1	20mm BLACK MARBLE TOP
CB1	CABINET	MC2	20mm MDF BOARD WITH GRAY WO LAMINATE ON TOP
CB2	LOCKER	MC3	METAL CABINET HANDLE
LS1	LOUNGE SOFA (LOUNGE AREA)	MC4	MDF BOARD TOEKICK WITH META SHEET FINSIHES
	MACHINERY	MC5	15mm BLACK CHOCK BOARD
KC1	SMALL FRIDGE	MC6	5mm TRANSPARENT GLASS
KC2	COFFEE MACHINE	MC7	10MM MDF SHELVE BAORD
КС3	MOUNTED CUP DISPENSER	MC8	90X45mm SUPPORTING TIMBER B
KC5	CAKE MACHINE	MC9	W: 8mm, L:100, H: 1000mm, VERTIO



NO. DATE: REVISIONS:

ASSIGNMENT TITLE: DOCUMENTATION PROJECT (FINAL)

DRAWING TITLE: CAFE COUNTER ELEVATION A & ELEVATION B

NAME: BUNHANGLINA YEA

COURSE: SYSTEM AND DOCUMENTATION 3

TERM: 1


ASSIGNMENT NO.:4

LECTURER : SOPHIE LUCAS

DATE: 9 MAY 2020

SCALE: 1:10

12

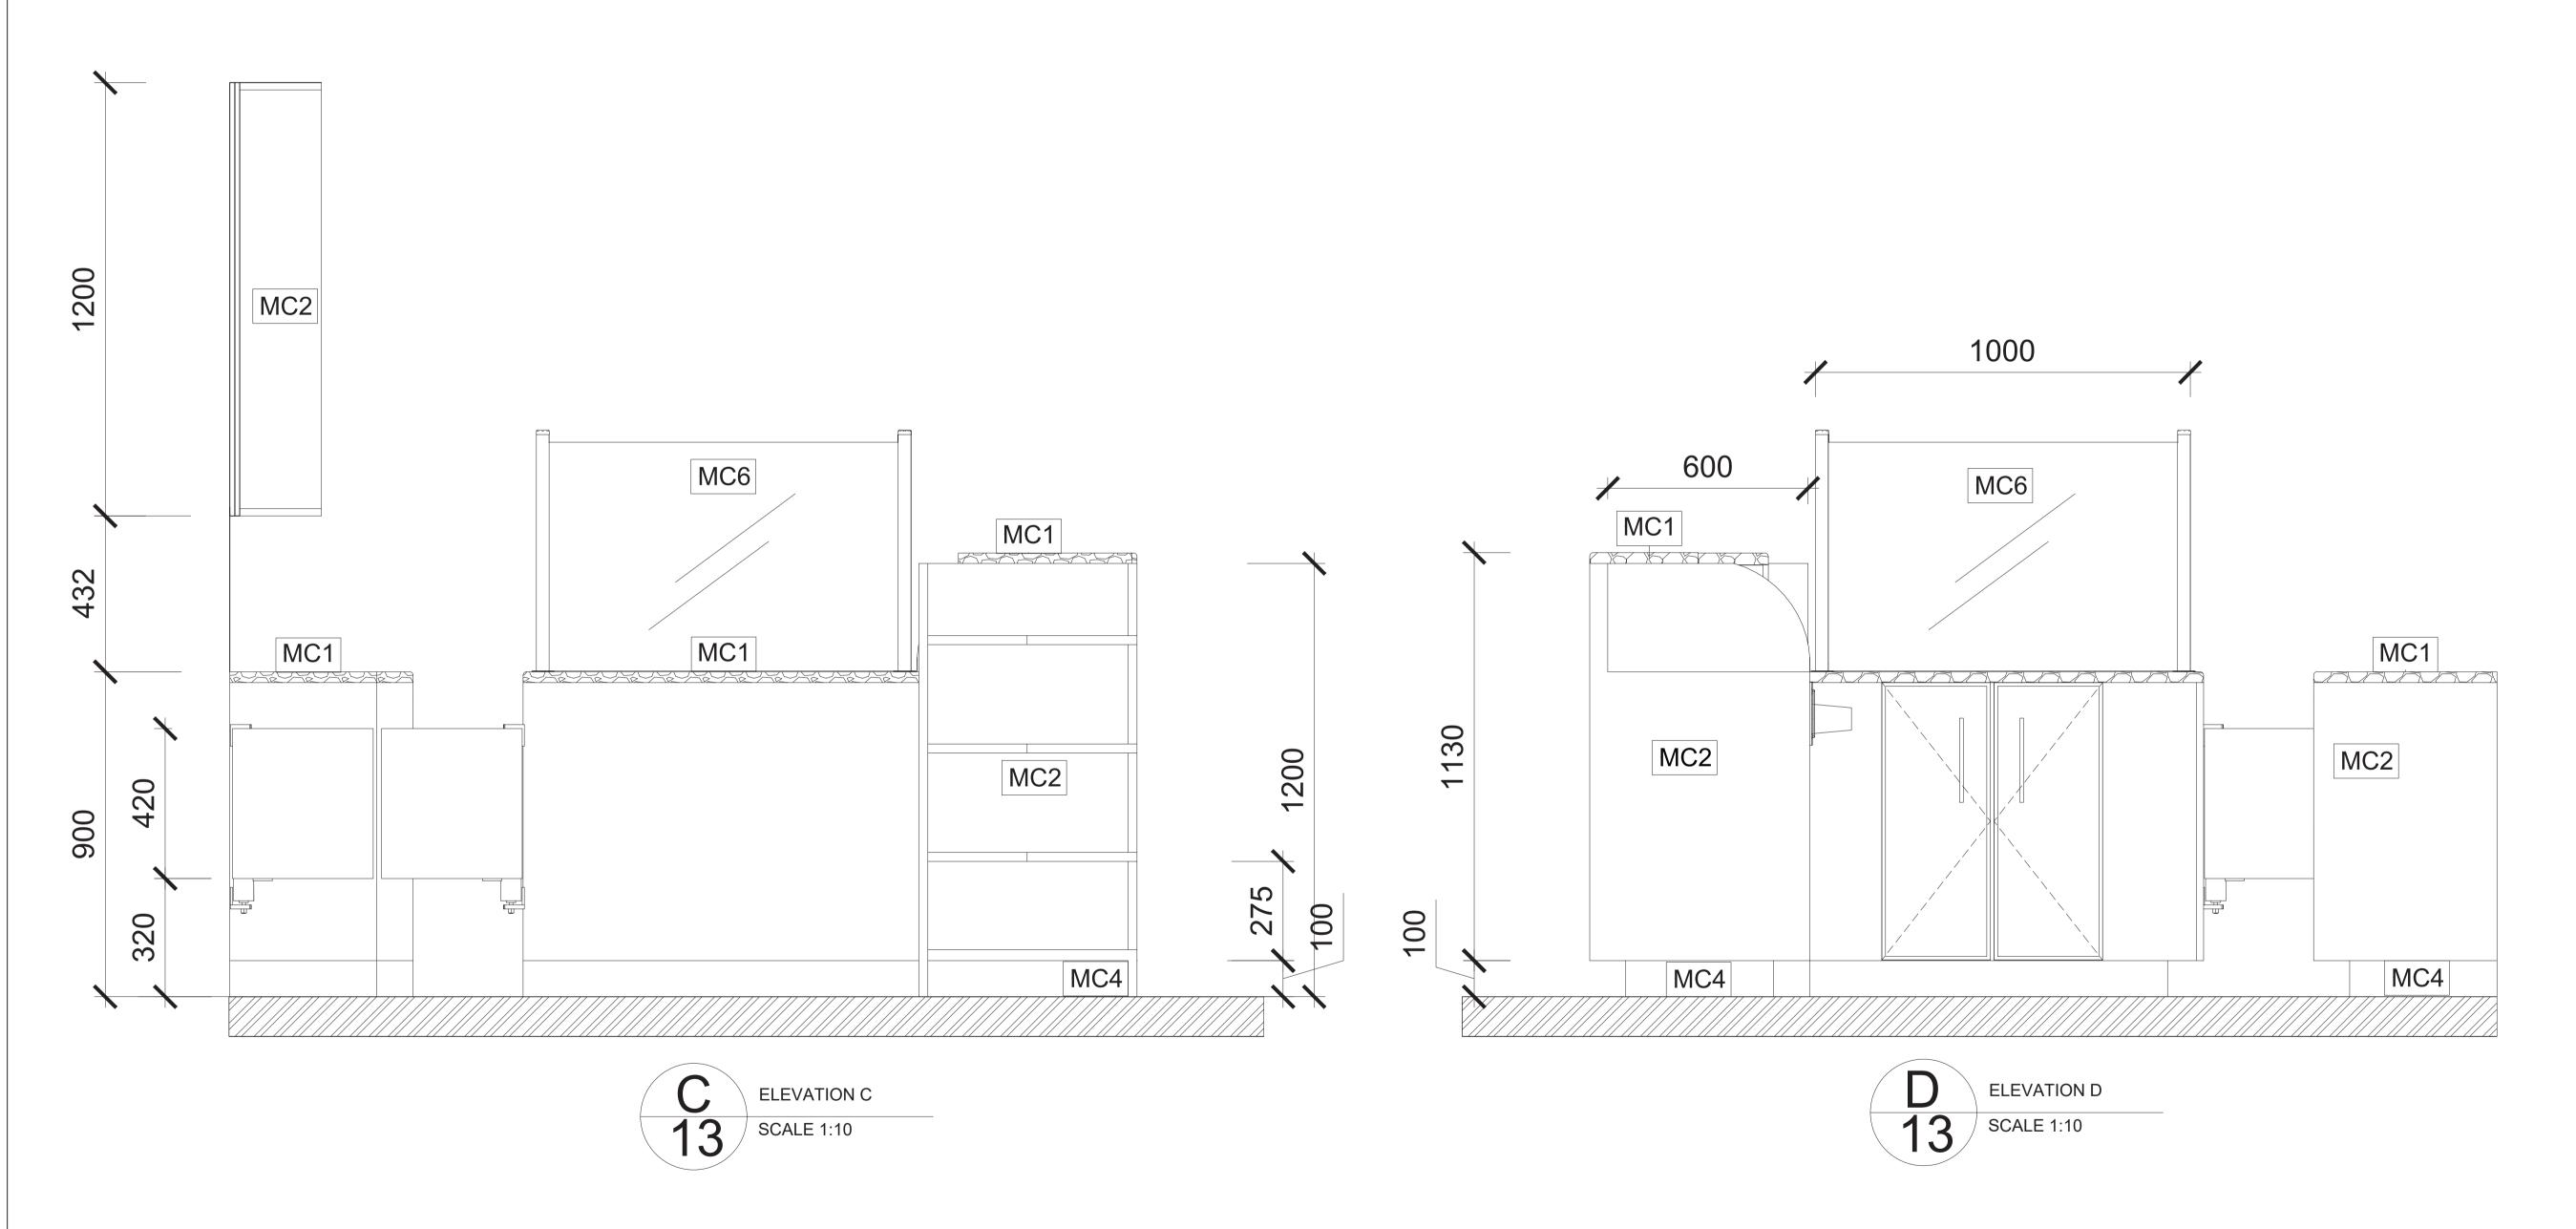

The contractor to be responsible for: - Verifying all drawings, specifications, dimensions and measurements as well as site, conditions and notifying the designer of all discrepancies and omissions before commencing the works.
- Submitting samples and shop drawings for review and approval by designer before commencing works. - Ensuring that all work is keeping with all International building codes.

- All necessary repairs, patching and cleaning of site during and after completition of works. - Verifying existing site conditions prior to submissions of quotations.

Not starting the construction unless these drawings are signed approved.
All work specified on all drawings and specifications and supplying all necessary materials and labour required to complete all phases of work in accordance with the designer's standards.

- All dimensions in millimeters

SPECIFIC NOTES:

	FURNITURE			
CODE	DISCRIPTION	CODE	DISCRIPTION	
WD1	WORKING DESK (HOT DESK AREA)	LC1	LOUNGE ARMCHAIR (LOUNGE AREA)	
WC1	WORKING CHAIR (HOT DESK AREA)	BP2	BUILD IN ISLAND COUNTER (PANTRY	
WD2	WORKING DESK (PRIVATE OFFICE)	BP3	BUILD IN KITCHEN COUNTER (PANTR	
WC2	WORKING CHAIR (PRIVATE OFFICE)	BT1	BUILD IN TV CABINET (METING ROOM	
MT1	MEETING TABLE	BC2	BUILD IN CASHIER CAFE COUNTER (CAFE)	
WC3	WORKING CHAIR (MEETING ROOM)	ВС3	BUILD IN CAFE COUNTER (CAFE)	
WT3	WORKING TABLE (SMALL PRIVATE OFFICE)	BC4	BUILD IN CAFE SHELVING(CAFE)	
WT4	WORKING TABLE (BIG PRIVATE OFFICE)	CB3	CABINET WITH PLANT ON TOP	
CA1	CAFE ARMCHAIR TYPE 1	FL1	FLOOR LAMP (LOUNGE)	
CT1	CAFE TABLE TYPE 1	PW1	PLANT PARTITION WALL	
CA2	CAFE ARMCHAIR TYPE 2	D01	MAIN GLASS SLIDING DOOR 2400mm	
CT2	CAFE TABLE TYPE 2	D02	SWING DOOR WITH METAL FRAME 900mm	
LT2	LOUNGE TABLE (SEATING AREA)	D03	SLIDING GLASS DOOR 1200mm	
BC1	BUILD IN RECEPTION COUNTER	D04	FOLDING DOOR 1200mm	
BP1	BUILD IN COUNTER (PANTRY)	D05	TOILET DOOR 900mm	
BB1	BUILD IN PHONE BOOTH	D06	TOILET ENTRANCE DOOR 900mm	
CC1	COUNTER CHAIR (PANTRY)	W01	GLASS WINDOW (FRONT BUILDING)	
BS1	BUILD IN STAIR SEAT(PANTRY)	W02	2- GLASS WINDOW	
HC1	HANGING CHAIR (PANTRY)	W03	3- GLASS WINDOW	
HC2	HANGING CHAIR (NAP ROOM)		MATERIAL	
DB1	DAY BED (NAP ROOM)	SC1	WHITE GLOSSY FINISH CERAMIC TILE BACKSPLASH	
NB1	NAP BED (NAP ROOM)	MC1	20mm BLACK MARBLE TOP	
CB1	CABINET	MC2	20mm MDF BOARD WITH GRAY WOOL LAMINATE ON TOP	
CB2	LOCKER	MC3	METAL CABINET HANDLE	
LS1	LOUNGE SOFA (LOUNGE AREA)	MC4	MDF BOARD TOEKICK WITH METAL SHEET FINSIHES	
	MACHINERY	MC5	15mm BLACK CHOCK BOARD	
KC1	SMALL FRIDGE	MC6	5mm TRANSPARENT GLASS	
KC2	COFFEE MACHINE	MC7	10MM MDF SHELVE BAORD	
KC3	MOUNTED CUP DISPENSER	MC8	90X45mm SUPPORTING TIMBER BLOC	
		MC9		



NO. DATE: REVISIONS:

ASSIGNMENT TITLE: DOCUMENTATION PROJECT (FINAL)

DRAWING TITLE: CAFE COUNTER ELEVATION C & ELEVATION D

NAME: BUNHANGLINA YEA

COURSE: SYSTEM AND DOCUMENTATION 3


TERM: 1

ASSIGNMENT NO.:4

LECTURER : SOPHIE LUCAS


DATE: 10 MAY 2020

SCALE: 1:10

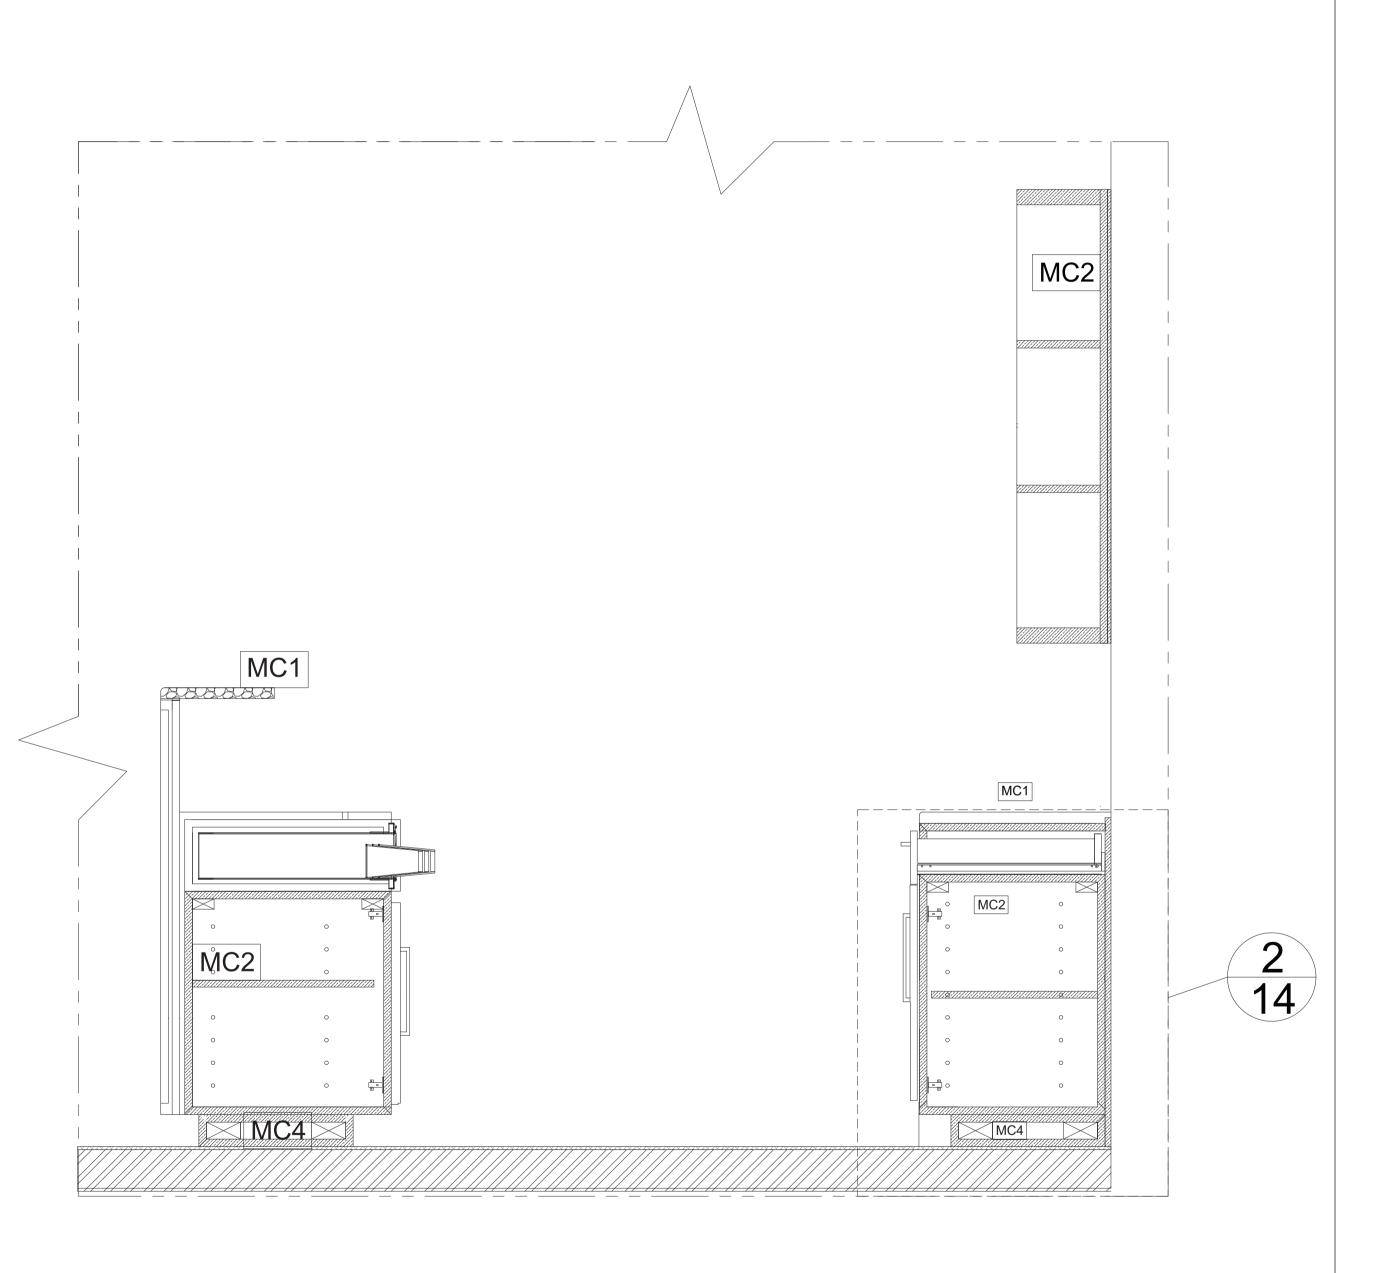

COUNTER SECTION 1

SCALE 1:10

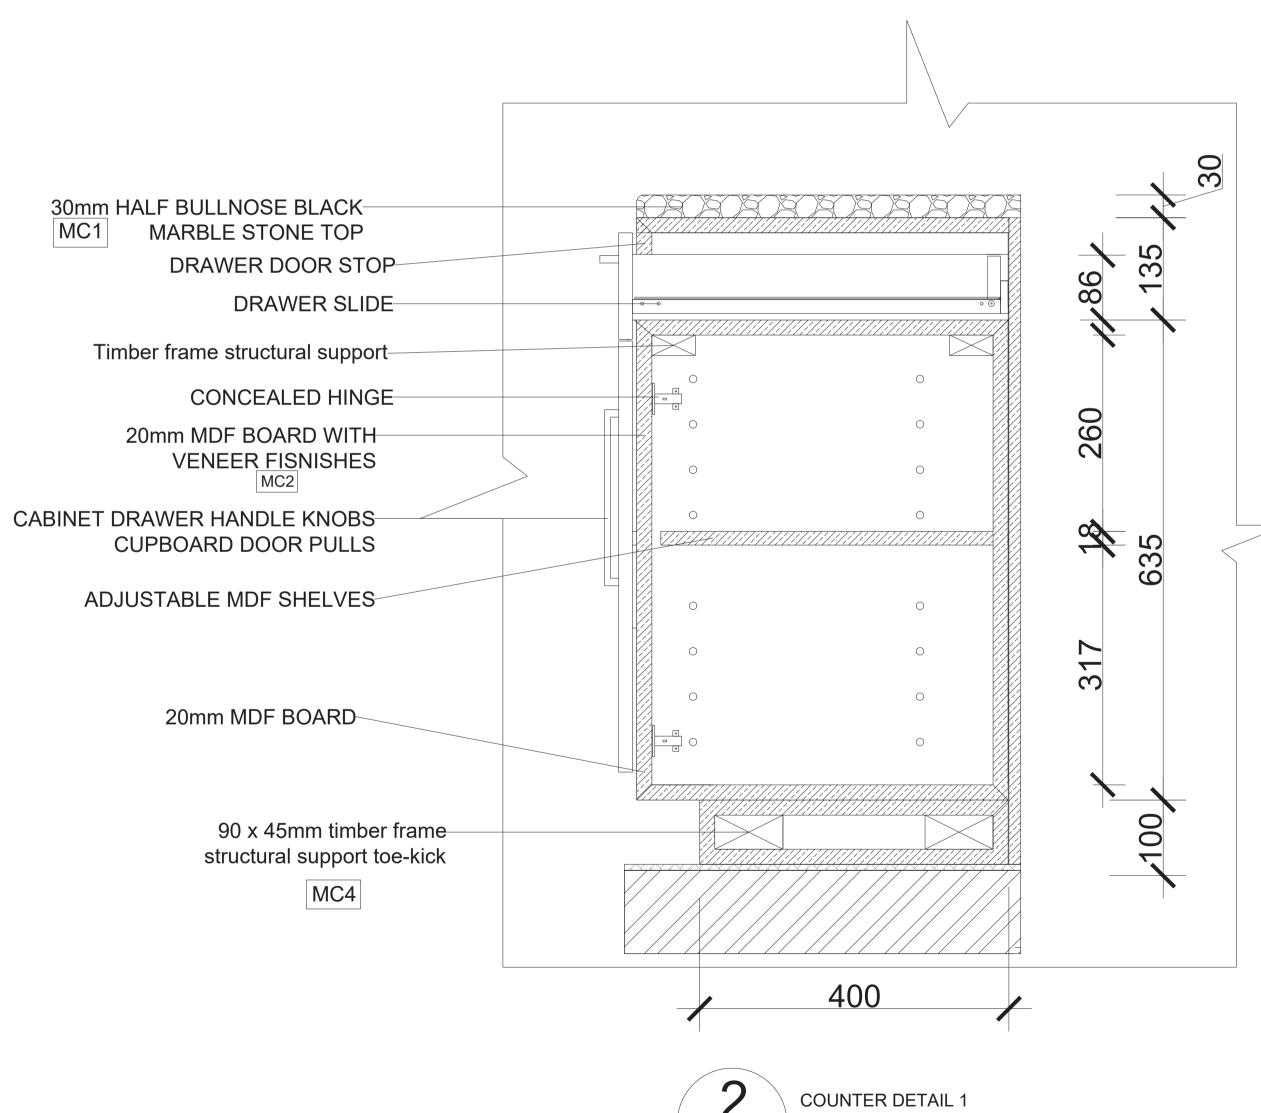

SCALE 1:5

GENERAL NOTES

The contractor to be responsible for: - Verifying all drawings, specifications,dimensions and measurements as well as site, conditions and notifying the designer of all discrepancies and omissions before commencing the works. - Submitting samples and shop drawings for review and approval by designer before commencing works. - Ensuring that all work is keeping with all

International building codes. All necessary repairs, patching and cleaning of site during and after completition of works. - Verifying existing site conditions prior to submissions of quotations. - Not starting the construction unless these

drawings are signed approved. - All work specified on all drawings and specifications and supplying all necessary materials and labour required to complete all phases of work in accordance with the designer's standards. - All dimensions in millimeters

SPECIFIC NOTES:

	FURNI	TORE	
CODE	DISCRIPTION	CODE	DISCRIPTION
WD1	WORKING DESK (HOT DESK AREA)	LC1	LOUNGE ARMCHAIR (LOUNGE AREA)
WC1	WORKING CHAIR (HOT DESK AREA)	BP2	BUILD IN ISLAND COUNTER (PANTRY)
WD2	WORKING DESK (PRIVATE OFFICE)	BP3	BUILD IN KITCHEN COUNTER (PANTR'
WC2	WORKING CHAIR (PRIVATE OFFICE)	BT1	BUILD IN TV CABINET (METING ROOM
MT1	MEETING TABLE	BC2	BUILD IN CASHIER CAFE COUNTER (CAFE)
WC3	WORKING CHAIR (MEETING ROOM)	ВС3	BUILD IN CAFE COUNTER (CAFE)
WT3	WORKING TABLE (SMALL PRIVATE OFFICE)	BC4	BUILD IN CAFE SHELVING(CAFE)
WT4	WORKING TABLE (BIG PRIVATE OFFICE)	СВЗ	CABINET WITH PLANT ON TOP
CA1	CAFE ARMCHAIR TYPE 1	FL1	FLOOR LAMP (LOUNGE)
CT1	CAFE TABLE TYPE 1	PW1	PLANT PARTITION WALL
CA2	CAFE ARMCHAIR TYPE 2	D01	MAIN GLASS SLIDING DOOR 2400mm
CT2	CAFE TABLE TYPE 2	D02	SWING DOOR WITH METAL FRAME 900mm
LT2	LOUNGE TABLE (SEATING AREA)	D03	SLIDING GLASS DOOR 1200mm
BC1	BUILD IN RECEPTION COUNTER	D04	FOLDING DOOR 1200mm
BP1	BUILD IN COUNTER (PANTRY)	D05	TOILET DOOR 900mm
BB1	BUILD IN PHONE BOOTH	D06	TOILET ENTRANCE DOOR 900mm
CC1	COUNTER CHAIR (PANTRY)	W01	GLASS WINDOW (FRONT BUILDING)
BS1	BUILD IN STAIR SEAT(PANTRY)	W02	2- GLASS WINDOW
HC1	HANGING CHAIR (PANTRY)	W03	3- GLASS WINDOW
HC2	HANGING CHAIR (NAP ROOM)		MATERIAL
DB1	DAY BED (NAP ROOM)	SC1	WHITE GLOSSY FINISH CERAMIC TILE BACKSPLASH
NB1	NAP BED (NAP ROOM)	MC1	20mm BLACK MARBLE TOP
CB1	CABINET	MC2	20mm MDF BOARD WITH GRAY WOOD LAMINATE ON TOP
CB2	LOCKER	MC3	METAL CABINET HANDLE
LS1	LOUNGE SOFA (LOUNGE AREA)	MC4	MDF BOARD TOEKICK WITH METAL SHEET FINSIHES
	MACHINERY	MC5	15mm BLACK CHOCK BOARD
KC1	SMALL FRIDGE	MC6	5mm TRANSPARENT GLASS
KC2	COFFEE MACHINE	MC7	10MM MDF SHELVE BAORD
КС3	MOUNTED CUP DISPENSER	MC8	90X45mm SUPPORTING TIMBER BLOC
KC5	CAKE MACHINE	MC9	W: 8mm, L:100, H: 1000mm, VERTICAL WOOD PANEL



NO. DATE: REVISIONS:

ASSIGNMENT TITLE: DOCUMENTATION PROJECT (FINAL)

DRAWING TITLE: CAFE COUNTER SECTION 1 & DETAIL 1

NAME: BUNHANGLINA YEA

COURSE: SYSTEM AND DOCUMENTATION 3


TERM: 1

ASSIGNMENT NO.:4


LECTURER : SOPHIE LUCAS

DATE: 10 MAY 2020

SCALE: 1:10

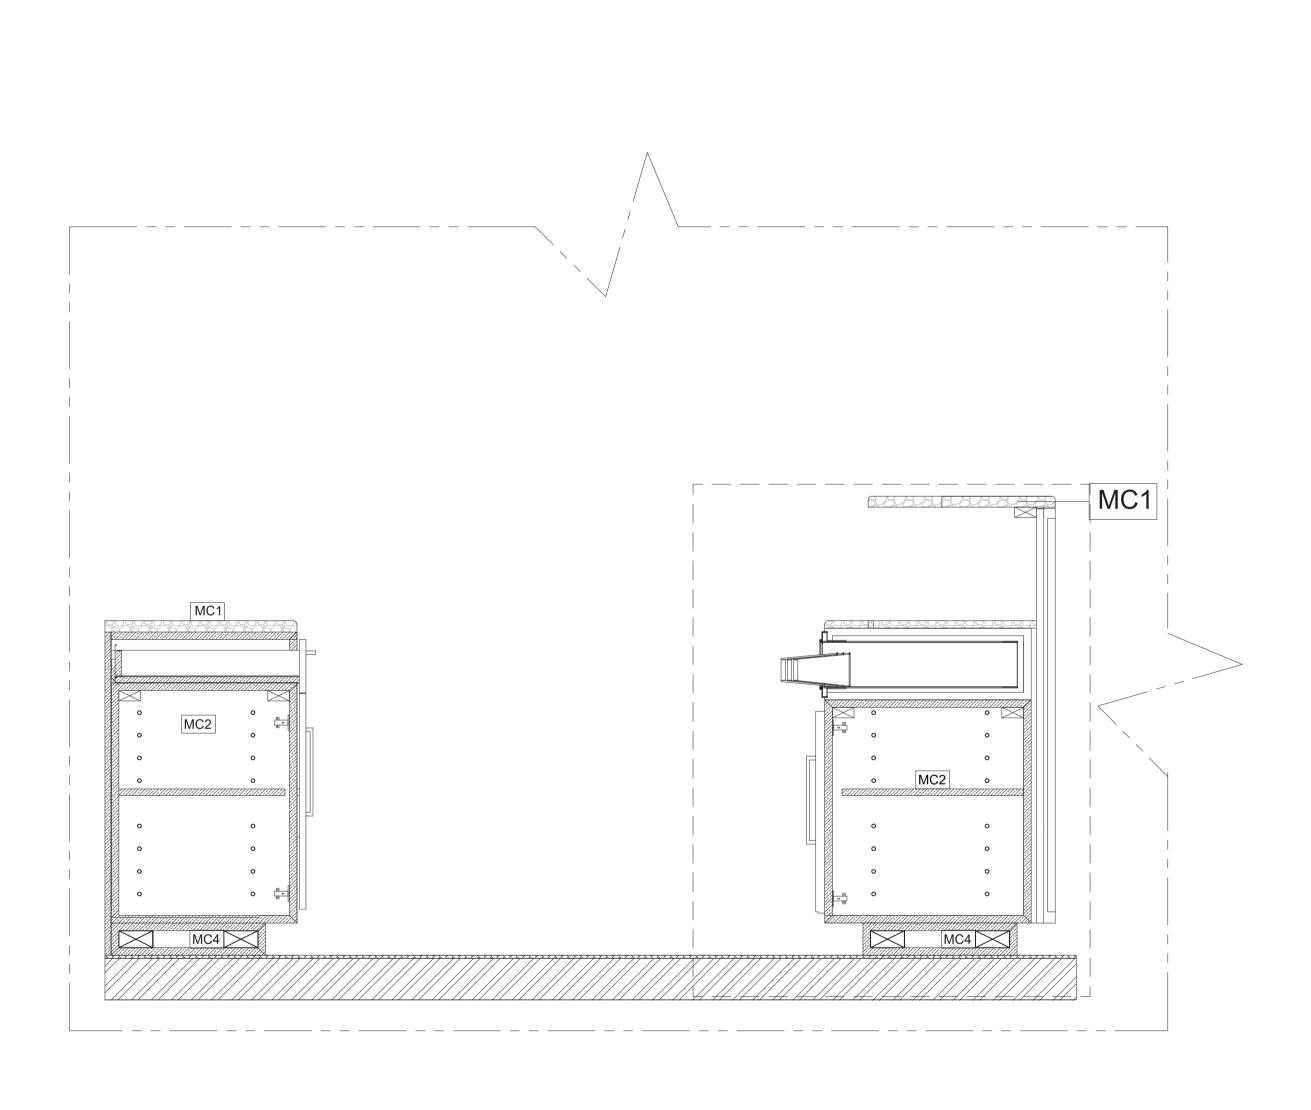

COUNTER SECTION 2 SCALE 1:10

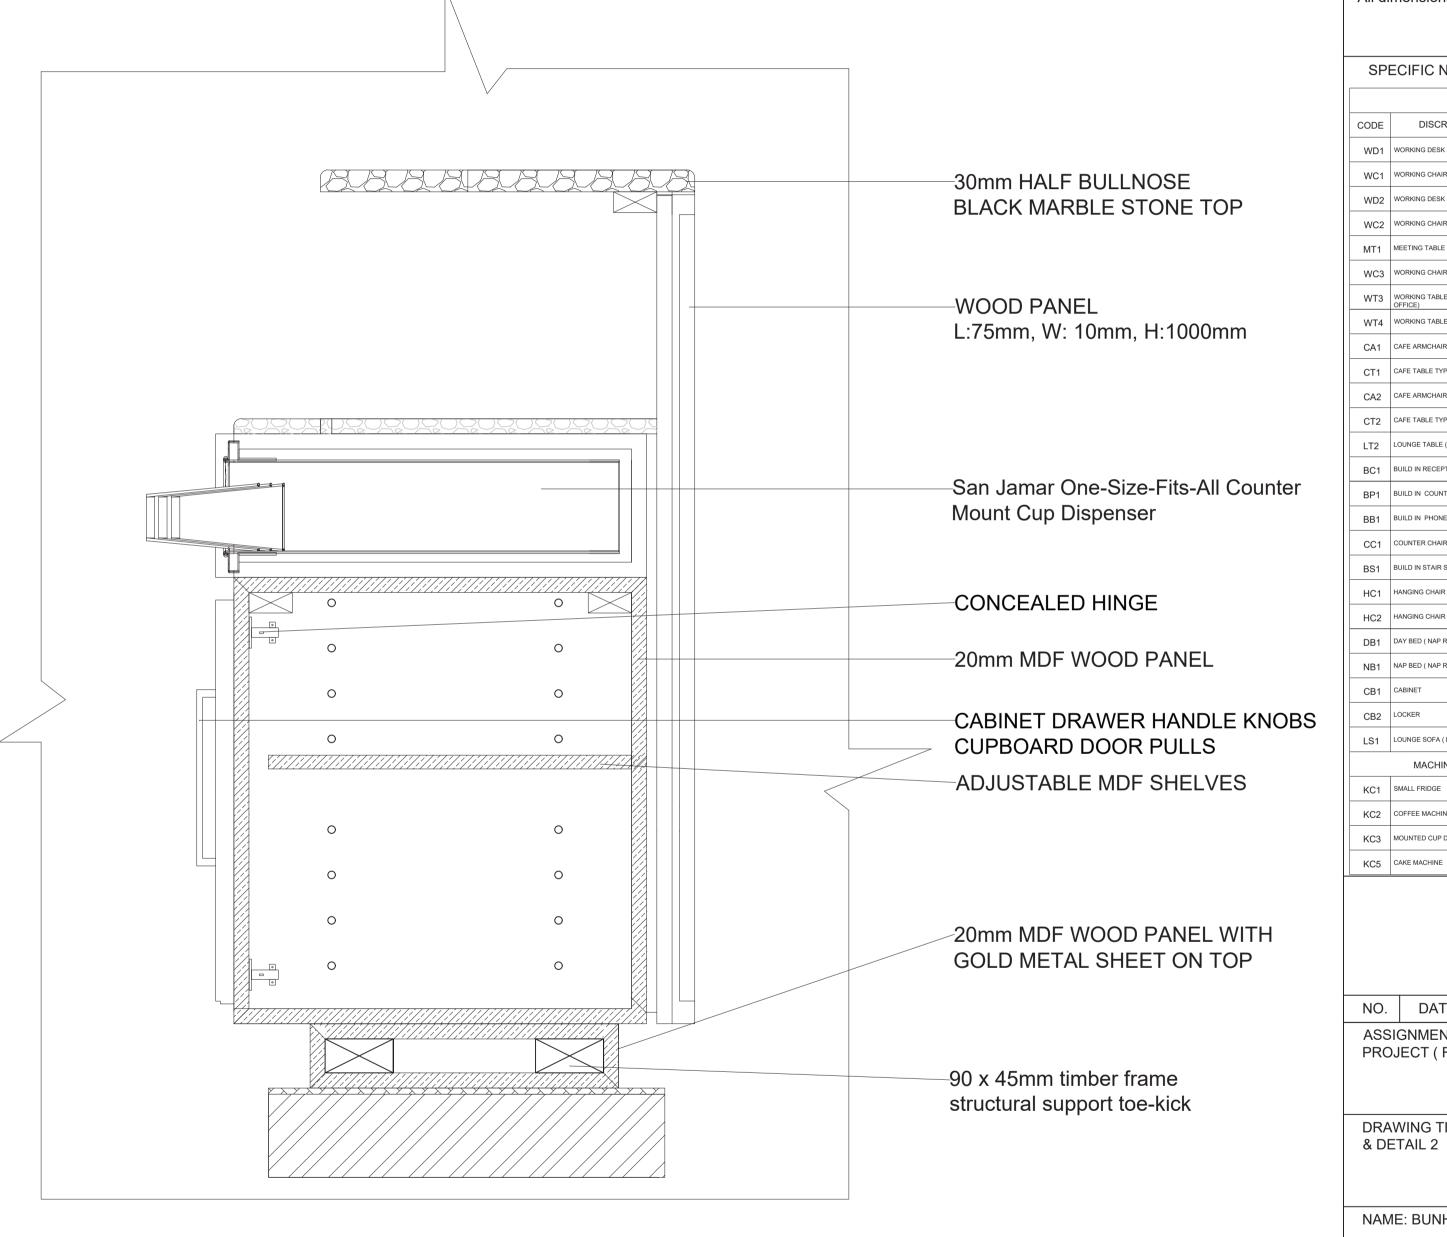

COUNTER DETAIL 2 SCALE 1:5

GENERAL NOTES

The contractor to be responsible for: - Verifying all drawings, specifications,dimensions and measurements as well as site, conditions and notifying the designer of all discrepancies and omissions before commencing the works. - Submitting samples and shop drawings for review and approval by designer before commencing works. - Ensuring that all work is keeping with all International building codes.

 All necessary repairs, patching and cleaning of site during and after completition of works. - Verifying existing site conditions prior to submissions of quotations.

Not starting the construction unless these drawings are signed approved.
All work specified on all drawings and specifications and supplying all necessary materials and labour required to complete all phases of work in accordance with the designer's standards.

- All dimensions in millimeters

SPECIFIC NOTES:

	FURNI	TURE	
CODE	DISCRIPTION	CODE	DISCRIPTION
WD1	WORKING DESK (HOT DESK AREA)	LC1	LOUNGE ARMCHAIR (LOUNGE AREA)
WC1	WORKING CHAIR (HOT DESK AREA)	BP2	BUILD IN ISLAND COUNTER (PANTRY)
WD2	WORKING DESK (PRIVATE OFFICE)	BP3	BUILD IN KITCHEN COUNTER (PANTR)
WC2	WORKING CHAIR (PRIVATE OFFICE)	BT1	BUILD IN TV CABINET (METING ROOM
MT1	MEETING TABLE	BC2	BUILD IN CASHIER CAFE COUNTER (CAFE)
WC3	WORKING CHAIR (MEETING ROOM)	вс3	BUILD IN CAFE COUNTER (CAFE)
WT3	WORKING TABLE (SMALL PRIVATE OFFICE)	BC4	BUILD IN CAFE SHELVING(CAFE)
WT4	WORKING TABLE (BIG PRIVATE OFFICE)	СВЗ	CABINET WITH PLANT ON TOP
CA1	CAFE ARMCHAIR TYPE 1	FL1	FLOOR LAMP (LOUNGE)
CT1	CAFE TABLE TYPE 1	PW1	PLANT PARTITION WALL
CA2	CAFE ARMCHAIR TYPE 2	D01	MAIN GLASS SLIDING DOOR 2400mm
CT2	CAFE TABLE TYPE 2	D02	SWING DOOR WITH METAL FRAME 900mm
LT2	LOUNGE TABLE (SEATING AREA)	D03	SLIDING GLASS DOOR 1200mm
BC1	BUILD IN RECEPTION COUNTER	D04	FOLDING DOOR 1200mm
BP1	BUILD IN COUNTER (PANTRY)	D05	TOILET DOOR 900mm
BB1	BUILD IN PHONE BOOTH	D06	TOILET ENTRANCE DOOR 900mm
CC1	COUNTER CHAIR (PANTRY)	W01	GLASS WINDOW (FRONT BUILDING)
BS1	BUILD IN STAIR SEAT(PANTRY)	W02	2- GLASS WINDOW
HC1	HANGING CHAIR (PANTRY)	W03	3- GLASS WINDOW
HC2	HANGING CHAIR (NAP ROOM)		MATERIAL
DB1	DAY BED (NAP ROOM)	SC1	WHITE GLOSSY FINISH CERAMIC TILE BACKSPLASH
NB1	NAP BED (NAP ROOM)	MC1	20mm BLACK MARBLE TOP
CB1	CABINET	MC2	20mm MDF BOARD WITH GRAY WOOD LAMINATE ON TOP
CB2	LOCKER	MC3	METAL CABINET HANDLE
LS1	LOUNGE SOFA (LOUNGE AREA)	MC4	MDF BOARD TOEKICK WITH METAL SHEET FINSIHES
	MACHINERY	MC5	15mm BLACK CHOCK BOARD
KC1	SMALL FRIDGE	MC6	5mm TRANSPARENT GLASS
KC2	COFFEE MACHINE	MC7	10MM MDF SHELVE BAORD
КС3	MOUNTED CUP DISPENSER	MC8	90X45mm SUPPORTING TIMBER BLOC
KC5	CAKE MACHINE	MC9	W: 8mm, L:100, H: 1000mm, VERTICAL WOOD PANEL



NO. DATE: REVISIONS: ASSIGNMENT TITLE: DOCUMENTATION PROJECT (FINAL)

DRAWING TITLE: CAFE COUNTER SECTION 2

NAME: BUNHANGLINA YEA

COURSE: SYSTEM AND DOCUMENTATION 3


TERM: 1

ASSIGNMENT NO.:4

LECTURER: SOPHIE LUCAS

DATE: 10 MAY 2020

SCALE: 1:10

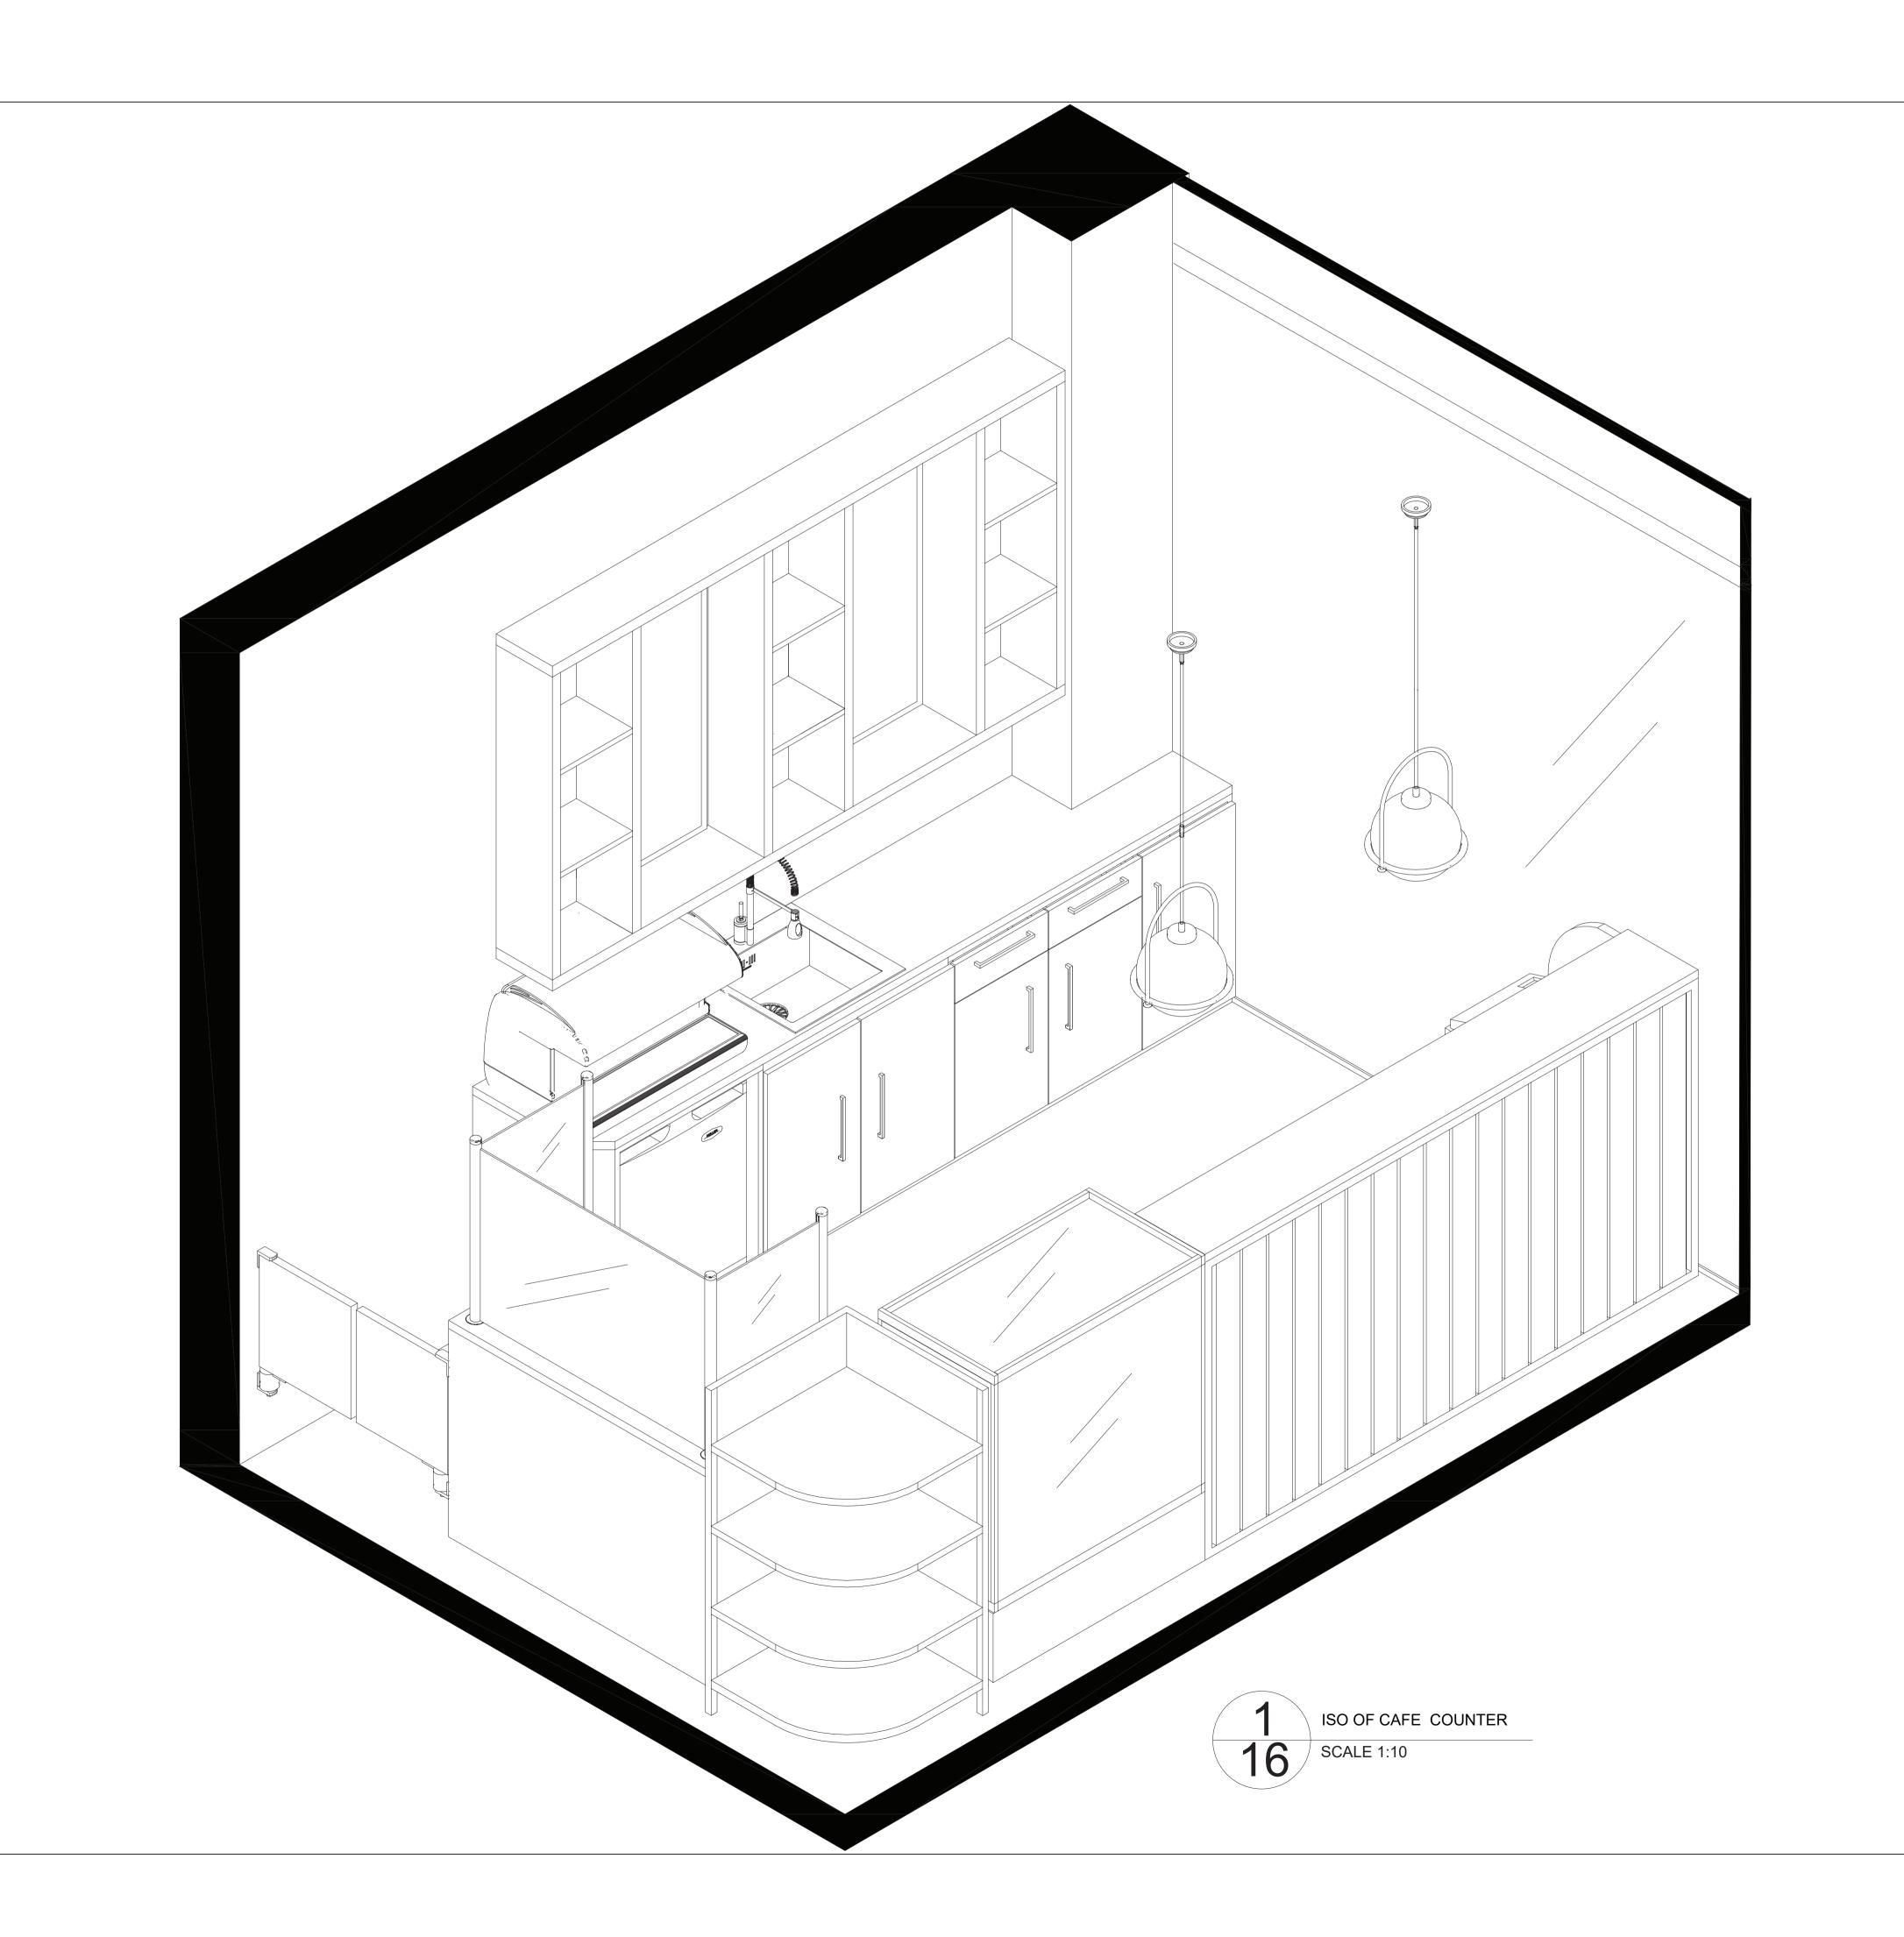

The contractor to be responsible for:
Verifying all drawings, specifications, dimensions and measurements as well as site, conditions and notifying the designer of all discrepancies and omissions before commencing the works.
Submitting samples and shop drawings for review and approval by designer before commencing works.
Ensuring that all work is keeping with all International building codes.
All necessary repairs, patching and cleaning of site during and after completition of works.
Verifying existing site conditions prior to submissions of quotations.
Not starting the construction unless these drawings are signed approved.
All work specified on all drawings and specifications and supplying all necessary

- specifications and supplying all necessary
 materials and labour required to complete all
 phases of work in accordance with the designer's
- standards. - All dimensions in millimeters

SPECIFIC NOTES:

OI	LOII IO NOTES.		
	FURNI	TURE	
CODE	DISCRIPTION	CODE	DISCRIPTION
WD1	WORKING DESK (HOT DESK AREA)	LC1	LOUNGE ARMCHAIR (LOUNGE AREA)
WC1	WORKING CHAIR (HOT DESK AREA)	BP2	BUILD IN ISLAND COUNTER (PANTRY)
WD2	WORKING DESK (PRIVATE OFFICE)	BP3	BUILD IN KITCHEN COUNTER (PANTRY
WC2	WORKING CHAIR (PRIVATE OFFICE)	BT1	BUILD IN TV CABINET (METING ROOM)
MT1	MEETING TABLE	BC2	BUILD IN CASHIER CAFE COUNTER (CAFE)
WC3	WORKING CHAIR (MEETING ROOM)	ВС3	BUILD IN CAFE COUNTER (CAFE)
WT3	WORKING TABLE (SMALL PRIVATE OFFICE)	BC4	BUILD IN CAFE SHELVING(CAFE)
WT4	WORKING TABLE (BIG PRIVATE OFFICE)	CB3	CABINET WITH PLANT ON TOP
CA1	CAFE ARMCHAIR TYPE 1	FL1	FLOOR LAMP (LOUNGE)
CT1	CAFE TABLE TYPE 1	PW1	PLANT PARTITION WALL
CA2	CAFE ARMCHAIR TYPE 2	D01	MAIN GLASS SLIDING DOOR 2400mm
CT2	CAFE TABLE TYPE 2	D02	SWING DOOR WITH METAL FRAME 900mm
LT2	LOUNGE TABLE (SEATING AREA)	D03	SLIDING GLASS DOOR 1200mm
BC1	BUILD IN RECEPTION COUNTER	D04	FOLDING DOOR 1200mm
BP1	BUILD IN COUNTER (PANTRY)	D05	TOILET DOOR 900mm
BB1	BUILD IN PHONE BOOTH	D06	TOILET ENTRANCE DOOR 900mm
CC1	COUNTER CHAIR (PANTRY)	W01	GLASS WINDOW (FRONT BUILDING)
BS1	BUILD IN STAIR SEAT(PANTRY)	W02	2- GLASS WINDOW
HC1	HANGING CHAIR (PANTRY)	W03	3- GLASS WINDOW
HC2	HANGING CHAIR (NAP ROOM)		MATERIAL
DB1	DAY BED (NAP ROOM)	SC1	WHITE GLOSSY FINISH CERAMIC TILE BACKSPLASH
NB1	NAP BED (NAP ROOM)	MC1	20mm BLACK MARBLE TOP
CB1	CABINET	MC2	20mm MDF BOARD WITH GRAY WOOD LAMINATE ON TOP
CB2	LOCKER	MC3	METAL CABINET HANDLE
LS1	LOUNGE SOFA (LOUNGE AREA)	MC4	MDF BOARD TOEKICK WITH METAL SHEET FINSIHES
	MACHINERY	MC5	15mm BLACK CHOCK BOARD
KC1	SMALL FRIDGE	MC6	5mm TRANSPARENT GLASS
KC2	COFFEE MACHINE	MC7	10MM MDF SHELVE BAORD
KC3	MOUNTED CUP DISPENSER	MC8	90X45mm SUPPORTING TIMBER BLOCK
KC5	CAKE MACHINE	MC9	W: 8mm, L:100, H: 1000mm, VERTICAL WOOD PANEL



NO. DATE: REVISIONS:

ASSIGNMENT TITLE: DOCUMENTATION PROJECT (FINAL)

DRAWING TITLE: ISOMETRIC VIEW OF CAFE COUNTER

NAME: BUNHANGLINA YEA

COURSE: SYSTEM AND DOCUMENTATION 3

TERM: 1

ASSIGNMENT NO.:4


LECTURER : SOPHIE LUCAS

DATE: 10 MAY 2020

SHEET:

SCALE: 1:10



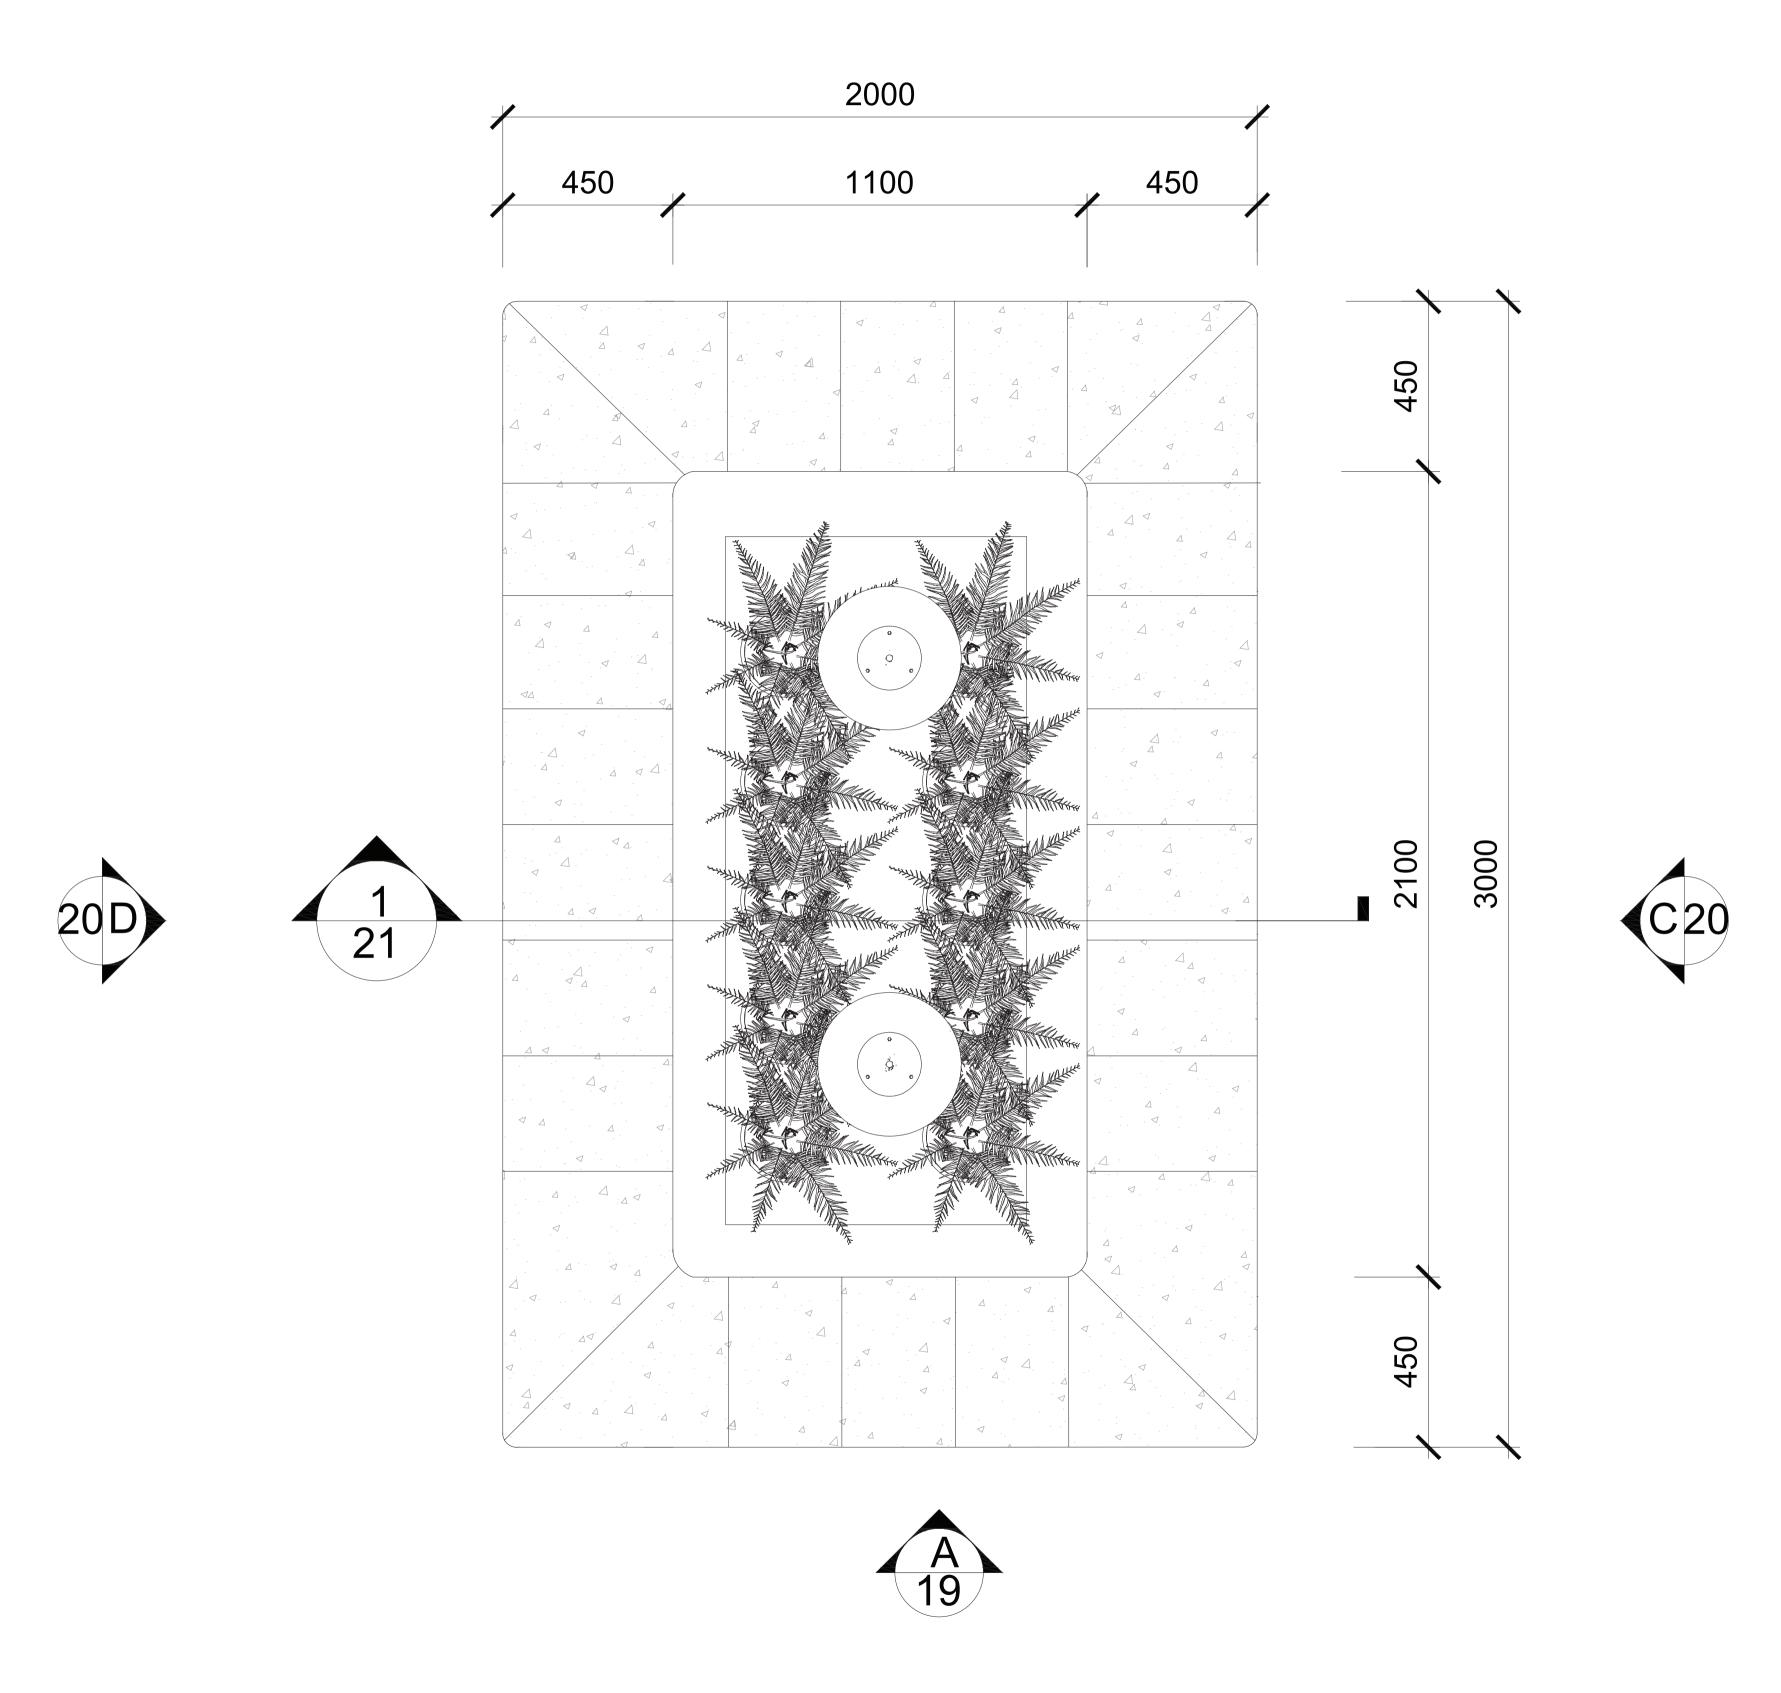



The contractor to be responsible for:

- Verifying all drawings, specifications, dimensions and measurements as well as site, conditions and notifying the designer of all discrepancies and omissions before commencing the works.

- Submitting samples and shop drawings for review and approval by designer before commencing works.

- Ensuring that all work is keeping with all International building codes.

- All necessary repairs, patching and cleaning of

All necessary repairs, patching and cleaning of site during and after completition of works.
Verifying existing site conditions prior to submissions of quotations.

Not starting the construction unless these drawings are signed approved.
All work specified on all drawings and specifications and supplying all necessary
materials and labour required to complete all
phases of work in accordance with the designer's standards.

- All dimensions in millimeters

SPECIFIC NOTES:

	FURNI	TURE	
CODE	DISCRIPTION	CODE	DISCRIPTION
WD1	WORKING DESK (HOT DESK AREA)	LC1	LOUNGE ARMCHAIR (LOUNGE AREA
WC1	WORKING CHAIR (HOT DESK AREA)	BP2	BUILD IN ISLAND COUNTER (PANTRY
WD2	WORKING DESK (PRIVATE OFFICE)	BP3	BUILD IN KITCHEN COUNTER (PANTE
WC2	WORKING CHAIR (PRIVATE OFFICE)	BT1	BUILD IN TV CABINET (METING ROOF
MT1	MEETING TABLE	BC2	BUILD IN CASHIER CAFE COUNTER (CAFE)
WC3	WORKING CHAIR (MEETING ROOM)	ВС3	BUILD IN CAFE COUNTER (CAFE)
WT3	WORKING TABLE (SMALL PRIVATE OFFICE)	BC4	BUILD IN CAFE SHELVING(CAFE)
WT4	WORKING TABLE (BIG PRIVATE OFFICE)	CB3	CABINET WITH PLANT ON TOP
CA1	CAFE ARMCHAIR TYPE 1	FL1	FLOOR LAMP (LOUNGE)
CT1	CAFE TABLE TYPE 1	PW1	PLANT PARTITION WALL
CA2	CAFE ARMCHAIR TYPE 2	D01	MAIN GLASS SLIDING DOOR 2400mm
CT2	CAFE TABLE TYPE 2	D02	SWING DOOR WITH METAL FRAME 900mm
LT2	LOUNGE TABLE (SEATING AREA)	D03	SLIDING GLASS DOOR 1200mm
BC1	BUILD IN RECEPTION COUNTER	D04	FOLDING DOOR 1200mm
BP1	BUILD IN COUNTER (PANTRY)	D05	TOILET DOOR 900mm
BB1	BUILD IN PHONE BOOTH	D06	TOILET ENTRANCE DOOR 900mm
CC1	COUNTER CHAIR (PANTRY)	W01	GLASS WINDOW (FRONT BUILDING)
BS1	BUILD IN STAIR SEAT(PANTRY)	W02	2- GLASS WINDOW
HC1	HANGING CHAIR (PANTRY)	W03	3- GLASS WINDOW
HC2	HANGING CHAIR (NAP ROOM)		MATERIAL
DB1	DAY BED (NAP ROOM)	SC1	WHITE GLOSSY FINISH CERAMIC TILI BACKSPLASH
NB1	NAP BED (NAP ROOM)	MC1	20mm BLACK MARBLE TOP
CB1	CABINET	MC2	20mm MDF BOARD WITH GRAY WOOLLAMINATE ON TOP
CB2	LOCKER	MC3	METAL CABINET HANDLE
LS1	LOUNGE SOFA (LOUNGE AREA)	MC4	MDF BOARD TOEKICK WITH METAL SHEET FINSIHES
	MACHINERY	MC5	15mm BLACK CHOCK BOARD
KC1	SMALL FRIDGE	MC6	5mm TRANSPARENT GLASS
KC2	COFFEE MACHINE	MC7	10MM MDF SHELVE BAORD
KC3	MOUNTED CUP DISPENSER	MC8	90X45mm SUPPORTING TIMBER BLOG
KC5	CAKE MACHINE	MC9	W: 8mm, L:100, H: 1000mm, VERTICAL WOOD PANEL



NO. DATE: REVISIONS:

ASSIGNMENT TITLE: DOCUMENTATION PROJECT (FINAL)

DRAWING TITLE: INTERNAL PLAN OF SEATING COUNTER

NAME: BUNHANGLINA YEA

COURSE: SYSTEM AND DOCUMENTATION 3

TERM: 1

ASSIGNMENT NO.:4


LECTURER : SOPHIE LUCAS


DATE: 9 MAY 2020

SCALE: 1:10

SHEET:

SEATING COUNTER INTERNAL PLAN

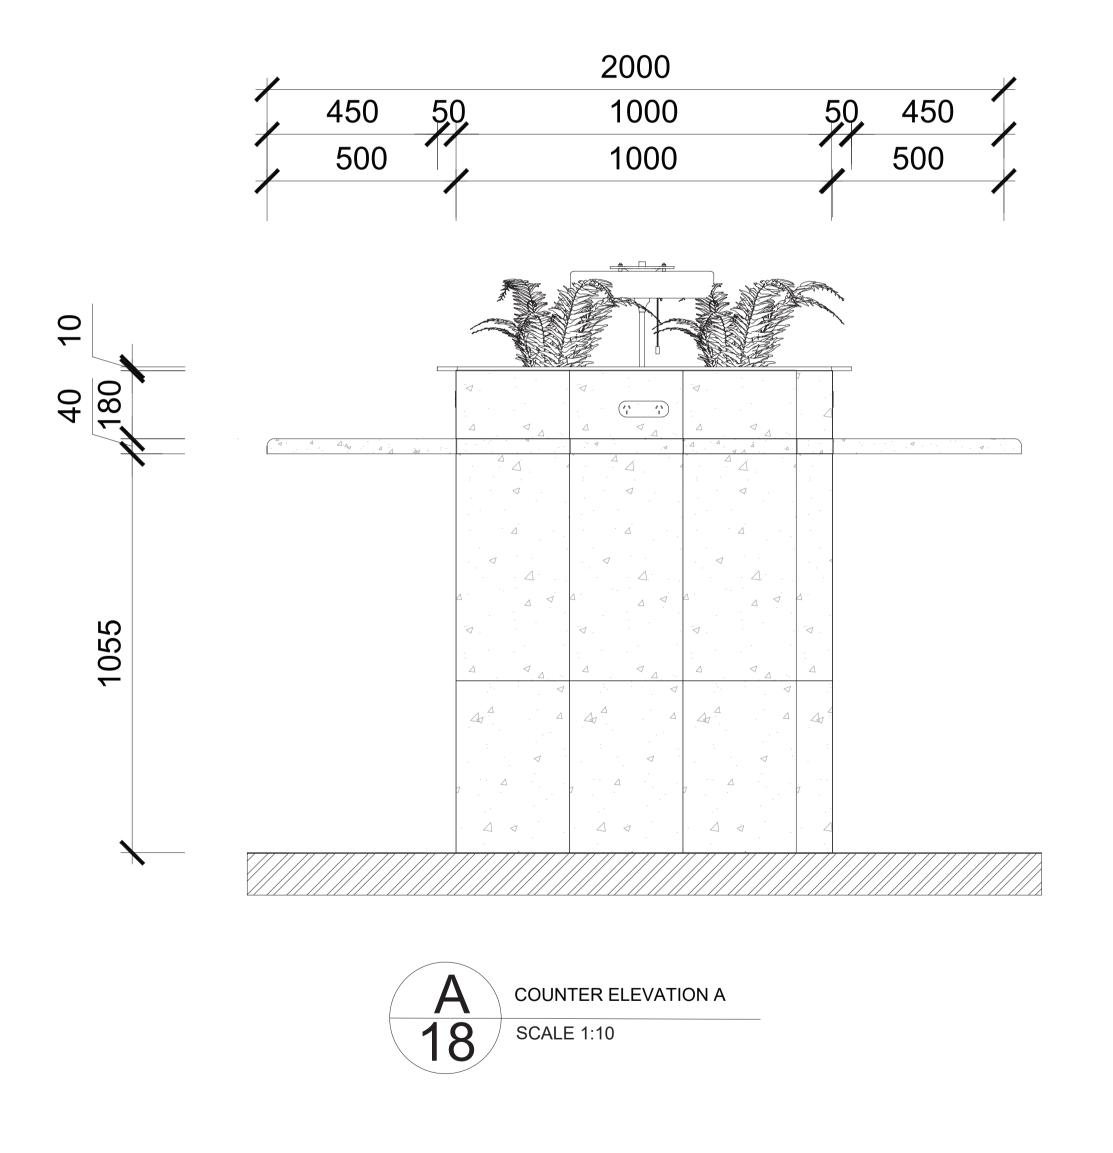

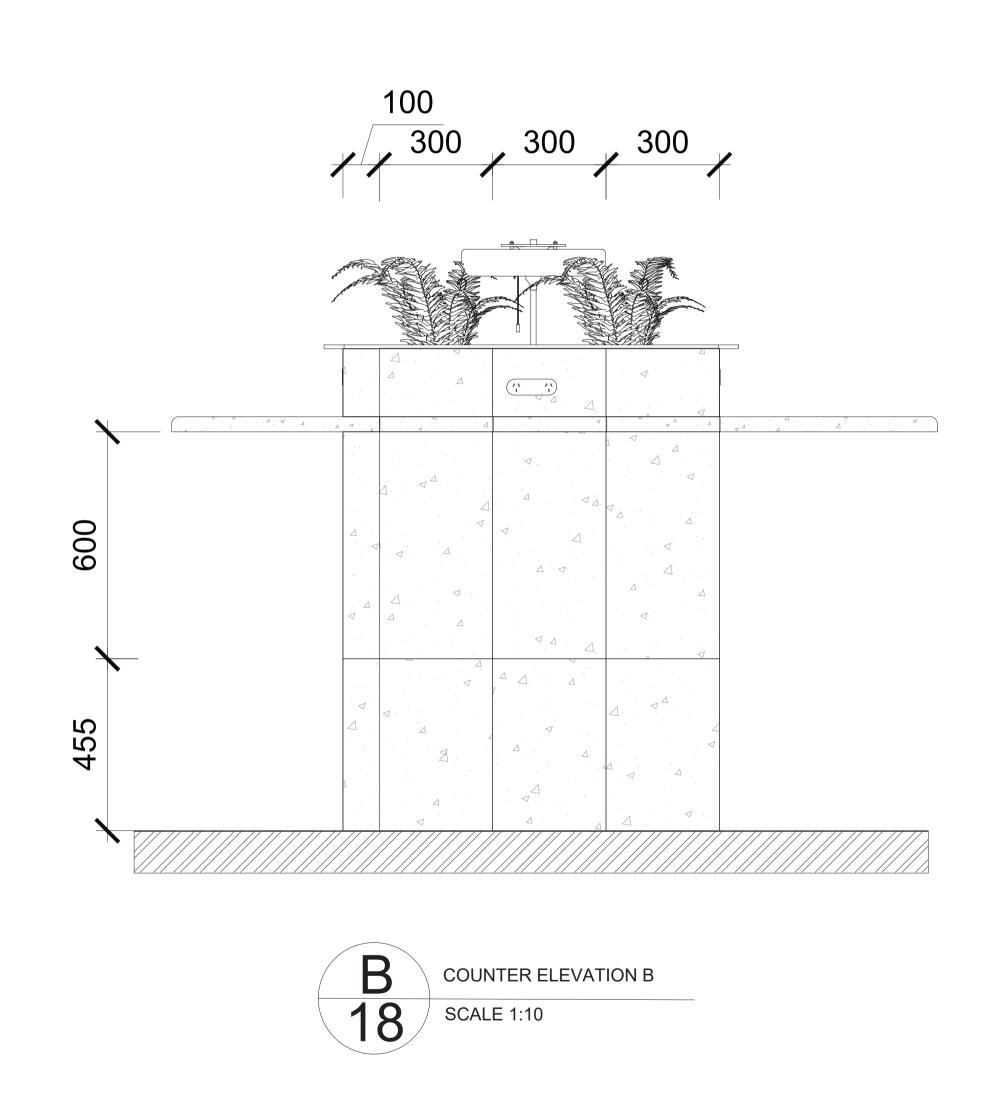

Verifying all drawings, specifications, dimensions and measurements as well as site, conditions and notifying the designer of all discrepancies and omissions before commencing the works.
Submitting samples and shop drawings for review and approval by designer before commencing works.
Ensuring that all work is keeping with all International building codes.
All necessary repairs, patching and cleaning of site during and after completition of works.

The contractor to be responsible for:

Verifying existing site conditions prior to submissions of quotations.
Not starting the construction unless these drawings are signed approved.

- All work specified on all drawings and specifications and supplying all necessary materials and labour required to complete all phases of work in accordance with the designer's standards.

- All dimensions in millimeters

SPECIFIC NOTES:

	FURNI	TURE	
CODE	DISCRIPTION	CODE	DISCRIPTION
WD1	WORKING DESK (HOT DESK AREA)	LC1	LOUNGE ARMCHAIR (LOUNGE AREA)
WC1	WORKING CHAIR (HOT DESK AREA)	BP2	BUILD IN ISLAND COUNTER (PANTRY
WD2	WORKING DESK (PRIVATE OFFICE)	BP3	BUILD IN KITCHEN COUNTER (PANTR
WC2	WORKING CHAIR (PRIVATE OFFICE)	BT1	BUILD IN TV CABINET (METING ROOM
MT1	MEETING TABLE	BC2	BUILD IN CASHIER CAFE COUNTER (CAFE)
WC3	WORKING CHAIR (MEETING ROOM)	ВС3	BUILD IN CAFE COUNTER (CAFE)
WT3	WORKING TABLE (SMALL PRIVATE OFFICE)	BC4	BUILD IN CAFE SHELVING(CAFE)
WT4	WORKING TABLE (BIG PRIVATE OFFICE)	СВЗ	CABINET WITH PLANT ON TOP
CA1	CAFE ARMCHAIR TYPE 1	FL1	FLOOR LAMP (LOUNGE)
CT1	CAFE TABLE TYPE 1	PW1	PLANT PARTITION WALL
CA2	CAFE ARMCHAIR TYPE 2	D01	MAIN GLASS SLIDING DOOR 2400mm
CT2	CAFE TABLE TYPE 2	D02	SWING DOOR WITH METAL FRAME 900mm
LT2	LOUNGE TABLE (SEATING AREA)	D03	SLIDING GLASS DOOR 1200mm
BC1	BUILD IN RECEPTION COUNTER	D04	FOLDING DOOR 1200mm
BP1	BUILD IN COUNTER (PANTRY)	D05	TOILET DOOR 900mm
BB1	BUILD IN PHONE BOOTH	D06	TOILET ENTRANCE DOOR 900mm
CC1	COUNTER CHAIR (PANTRY)	W01	GLASS WINDOW (FRONT BUILDING)
BS1	BUILD IN STAIR SEAT(PANTRY)	W02	2- GLASS WINDOW
HC1	HANGING CHAIR (PANTRY)	W03	3- GLASS WINDOW
HC2	HANGING CHAIR (NAP ROOM)	MATERIAL	
DB1	DAY BED (NAP ROOM)	SC1	WHITE GLOSSY FINISH CERAMIC TILE BACKSPLASH
NB1	NAP BED (NAP ROOM)	MC1	20mm BLACK MARBLE TOP
CB1	CABINET	MC2	20mm MDF BOARD WITH GRAY WOOL LAMINATE ON TOP
CB2	LOCKER	MC3	METAL CABINET HANDLE
LS1	LOUNGE SOFA (LOUNGE AREA)	MC4	MDF BOARD TOEKICK WITH METAL SHEET FINSIHES
	MACHINERY	MC5	15mm BLACK CHOCK BOARD
KC1	SMALL FRIDGE	MC6	5mm TRANSPARENT GLASS
KC2	COFFEE MACHINE	MC7	10MM MDF SHELVE BAORD
KC3	MOUNTED CUP DISPENSER	MC8	90X45mm SUPPORTING TIMBER BLOC
KC5	CAKE MACHINE	MC9	W: 8mm, L:100, H: 1000mm, VERTICAL WOOD PANEL



NO. DATE: REVISIONS:

ASSIGNMENT TITLE: DOCUMENTATION PROJECT (FINAL)

DRAWING TITLE: SEATING COUNTER ELEVATION A & ELEVATION B

NAME: BUNHANGLINA YEA

COURSE: SYSTEM AND DOCUMENTATION 3

TERM: 1

ASSIGNMENT NO.:4


LECTURER : SOPHIE LUCAS

DATE: 10 MAY 2020

SHEET:

SCALE: 1:10

18

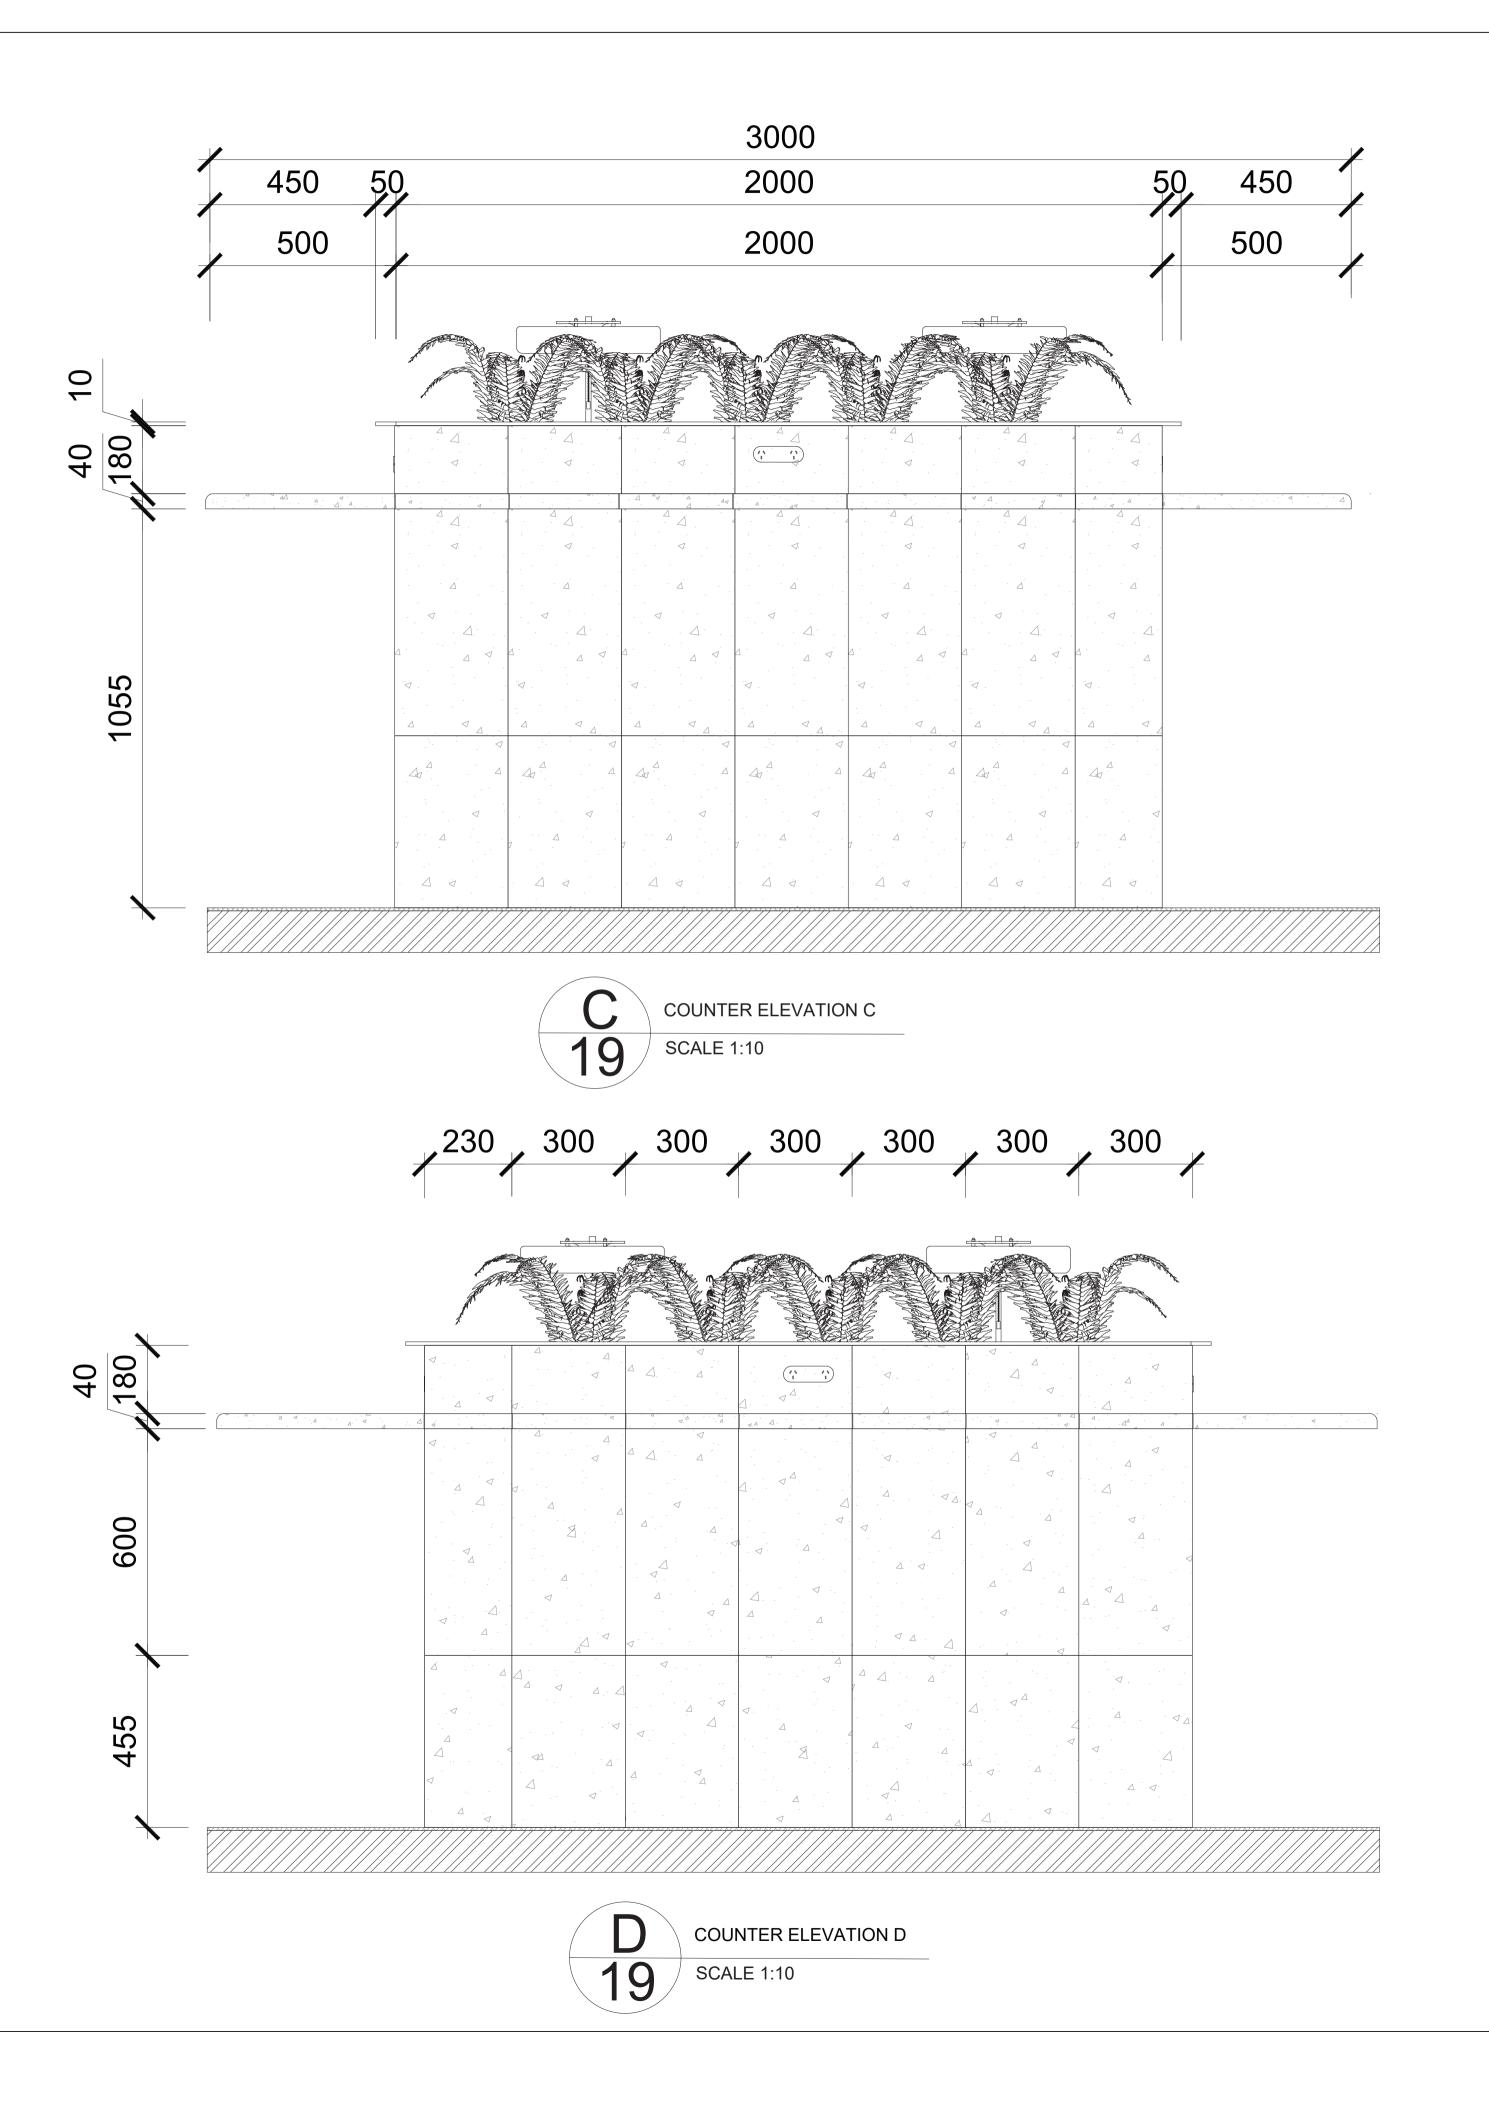

The contractor to be responsible for:
Verifying all drawings, specifications, dimensions and measurements as well as site, conditions and notifying the designer of all discrepancies and omissions before commencing the works.
Submitting samples and shop drawings for review and approval by designer before commencing works.
Ensuring that all work is keeping with all

International building codes.
All necessary repairs, patching and cleaning of site during and after completition of works.
Verifying existing site conditions prior to submissions of quotations.

Not starting the construction unless these drawings are signed approved.
All work specified on all drawings and specifications and supplying all necessary materials and labour required to complete all

phases of work in accordance with the designer's

standards.
- All dimensions in millimeters

SPECIFIC NOTES:

	FURNI	TURE	
CODE	DISCRIPTION	CODE	DISCRIPTION
WD1	WORKING DESK (HOT DESK AREA)	LC1	LOUNGE ARMCHAIR (LOUNGE AREA)
WC1	WORKING CHAIR (HOT DESK AREA)	BP2	BUILD IN ISLAND COUNTER (PANTRY
WD2	WORKING DESK (PRIVATE OFFICE)	BP3	BUILD IN KITCHEN COUNTER (PANTE
WC2	WORKING CHAIR (PRIVATE OFFICE)	BT1	BUILD IN TV CABINET (METING ROOM
MT1	MEETING TABLE	BC2	BUILD IN CASHIER CAFE COUNTER (CAFE)
WC3	WORKING CHAIR (MEETING ROOM)	ВС3	BUILD IN CAFE COUNTER (CAFE)
WT3	WORKING TABLE (SMALL PRIVATE OFFICE)	BC4	BUILD IN CAFE SHELVING(CAFE)
WT4	WORKING TABLE (BIG PRIVATE OFFICE)	CB3	CABINET WITH PLANT ON TOP
CA1	CAFE ARMCHAIR TYPE 1	FL1	FLOOR LAMP (LOUNGE)
CT1	CAFE TABLE TYPE 1	PW1	PLANT PARTITION WALL
CA2	CAFE ARMCHAIR TYPE 2	D01	MAIN GLASS SLIDING DOOR 2400mm
CT2	CAFE TABLE TYPE 2	D02	SWING DOOR WITH METAL FRAME 900mm
LT2	LOUNGE TABLE (SEATING AREA)	D03	SLIDING GLASS DOOR 1200mm
BC1	BUILD IN RECEPTION COUNTER	D04	FOLDING DOOR 1200mm
BP1	BUILD IN COUNTER (PANTRY)	D05	TOILET DOOR 900mm
BB1	BUILD IN PHONE BOOTH	D06	TOILET ENTRANCE DOOR 900mm
CC1	COUNTER CHAIR (PANTRY)	W01	GLASS WINDOW (FRONT BUILDING)
BS1	BUILD IN STAIR SEAT(PANTRY)	W02	2- GLASS WINDOW
HC1	HANGING CHAIR (PANTRY)	W03	3- GLASS WINDOW
HC2	HANGING CHAIR (NAP ROOM)		MATERIAL
DB1	DAY BED (NAP ROOM)	SC1	WHITE GLOSSY FINISH CERAMIC TILE BACKSPLASH
NB1	NAP BED (NAP ROOM)	MC1	20mm BLACK MARBLE TOP
CB1	CABINET	MC2	20mm MDF BOARD WITH GRAY WOOL LAMINATE ON TOP
CB2	LOCKER	MC3	METAL CABINET HANDLE
LS1	LOUNGE SOFA (LOUNGE AREA)	MC4	MDF BOARD TOEKICK WITH METAL SHEET FINSIHES
	MACHINERY	MC5	15mm BLACK CHOCK BOARD
KC1	SMALL FRIDGE	MC6	5mm TRANSPARENT GLASS
KC2	COFFEE MACHINE	MC7	10MM MDF SHELVE BAORD
KC3	MOUNTED CUP DISPENSER	MC8	90X45mm SUPPORTING TIMBER BLOC
KC5	CAKE MACHINE	MC9	W: 8mm, L:100, H: 1000mm, VERTICAL WOOD PANEL



NO. DATE: REVISIONS:

ASSIGNMENT TITLE: DOCUMENTATION PROJECT (FINAL)

DRAWING TITLE: SEATING COUNTER ELEVATION C & ELEVATION D

NAME: BUNHANGLINA YEA

COURSE: SYSTEM AND DOCUMENTATION 3

TERM: 1

ASSIGNMENT NO.:4


LECTURER : SOPHIE LUCAS


DATE: 10 MAY 2020

:10

SCALE: 1:10

19

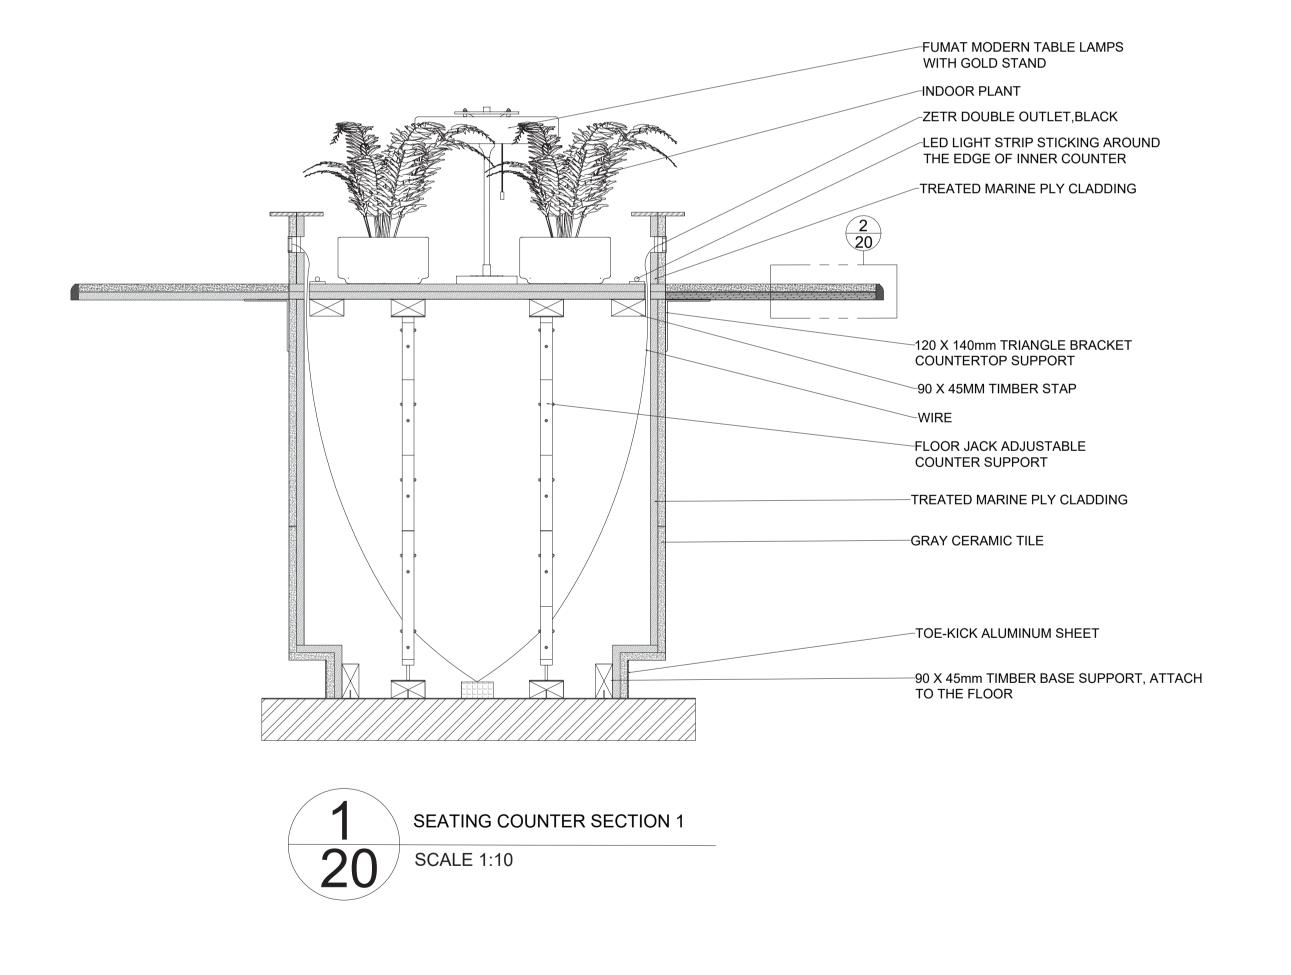

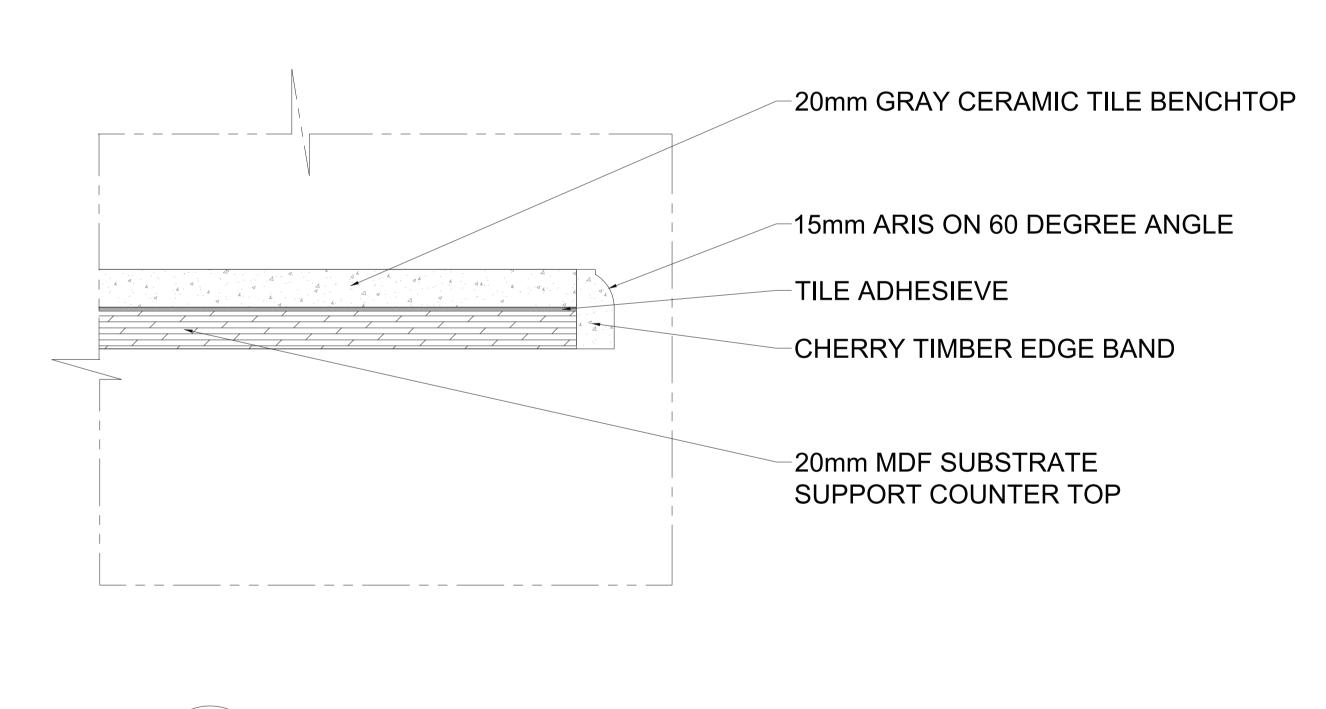

SEATING COUNTER SECTION DETAIL

SCALE 1:2

GENERAL NOTES

The contractor to be responsible for:
Verifying all drawings, specifications, dimensions and measurements as well as site, conditions and notifying the designer of all discrepancies and omissions before commencing the works.
Submitting samples and shop drawings for review and approval by designer before commencing works.
Ensuring that all work is keeping with all International building codes.

All necessary repairs, patching and cleaning of site during and after completition of works.
Verifying existing site conditions prior to submissions of quotations.
Not starting the construction unless these

drawings are signed approved.

- All work specified on all drawings and specifications and supplying all necessary materials and labour required to complete all phases of work in accordance with the designer's standards.

- All dimensions in millimeters

SPECIFIC NOTES:

	FURNI	TURE	
CODE	DISCRIPTION	CODE	DISCRIPTION
WD1	WORKING DESK (HOT DESK AREA)	LC1	LOUNGE ARMCHAIR (LOUNGE AREA)
WC1	WORKING CHAIR (HOT DESK AREA)	BP2	BUILD IN ISLAND COUNTER (PANTRY)
WD2	WORKING DESK (PRIVATE OFFICE)	BP3	BUILD IN KITCHEN COUNTER (PANTRY
WC2	WORKING CHAIR (PRIVATE OFFICE)	BT1	BUILD IN TV CABINET (METING ROOM
MT1	MEETING TABLE	BC2	BUILD IN CASHIER CAFE COUNTER (CAFE)
WC3	WORKING CHAIR (MEETING ROOM)	ВС3	BUILD IN CAFE COUNTER (CAFE)
WT3	WORKING TABLE (SMALL PRIVATE OFFICE)	BC4	BUILD IN CAFE SHELVING(CAFE)
WT4	WORKING TABLE (BIG PRIVATE OFFICE)	CB3	CABINET WITH PLANT ON TOP
CA1	CAFE ARMCHAIR TYPE 1	FL1	FLOOR LAMP (LOUNGE)
CT1	CAFE TABLE TYPE 1	PW1	PLANT PARTITION WALL
CA2	CAFE ARMCHAIR TYPE 2	D01	MAIN GLASS SLIDING DOOR 2400mm
CT2	CAFE TABLE TYPE 2	D02	SWING DOOR WITH METAL FRAME 900mm
LT2	LOUNGE TABLE (SEATING AREA)	D03	SLIDING GLASS DOOR 1200mm
BC1	BUILD IN RECEPTION COUNTER	D04	FOLDING DOOR 1200mm
BP1	BUILD IN COUNTER (PANTRY)	D05	TOILET DOOR 900mm
BB1	BUILD IN PHONE BOOTH	D06	TOILET ENTRANCE DOOR 900mm
CC1	COUNTER CHAIR (PANTRY)	W01	GLASS WINDOW (FRONT BUILDING)
BS1	BUILD IN STAIR SEAT(PANTRY)	W02	2- GLASS WINDOW
HC1	HANGING CHAIR (PANTRY)	W03	3- GLASS WINDOW
HC2	HANGING CHAIR (NAP ROOM)		MATERIAL
DB1	DAY BED (NAP ROOM)	SC1	WHITE GLOSSY FINISH CERAMIC TILE BACKSPLASH
NB1	NAP BED (NAP ROOM)	MC1	20mm BLACK MARBLE TOP
CB1	CABINET	MC2	20mm MDF BOARD WITH GRAY WOOD LAMINATE ON TOP
CB2	LOCKER	MC3	METAL CABINET HANDLE
LS1	LOUNGE SOFA (LOUNGE AREA)	MC4	MDF BOARD TOEKICK WITH METAL SHEET FINSIHES
	MACHINERY	MC5	15mm BLACK CHOCK BOARD
KC1	SMALL FRIDGE	MC6	5mm TRANSPARENT GLASS
KC2	COFFEE MACHINE	MC7	10MM MDF SHELVE BAORD
KC3	MOUNTED CUP DISPENSER	MC8	90X45mm SUPPORTING TIMBER BLOCK
KC5	CAKE MACHINE	MC9	W: 8mm, L:100, H: 1000mm, VERTICAL WOOD PANEL



NO. DATE: REVISIONS:

ASSIGNMENT TITLE: DOCUMENTATION PROJECT (FINAL)

DRAWING TITLE: SEATING COUNTER SECTION AND DETAIL

NAME: BUNHANGLINA YEA

COURSE: SYSTEM AND DOCUMENTATION 3

TERM: 1


ASSIGNMENT NO.:4

LECTURER : SOPHIE LUCAS

DATE: 10 MAY 2020

SCALE: 1:2

-20

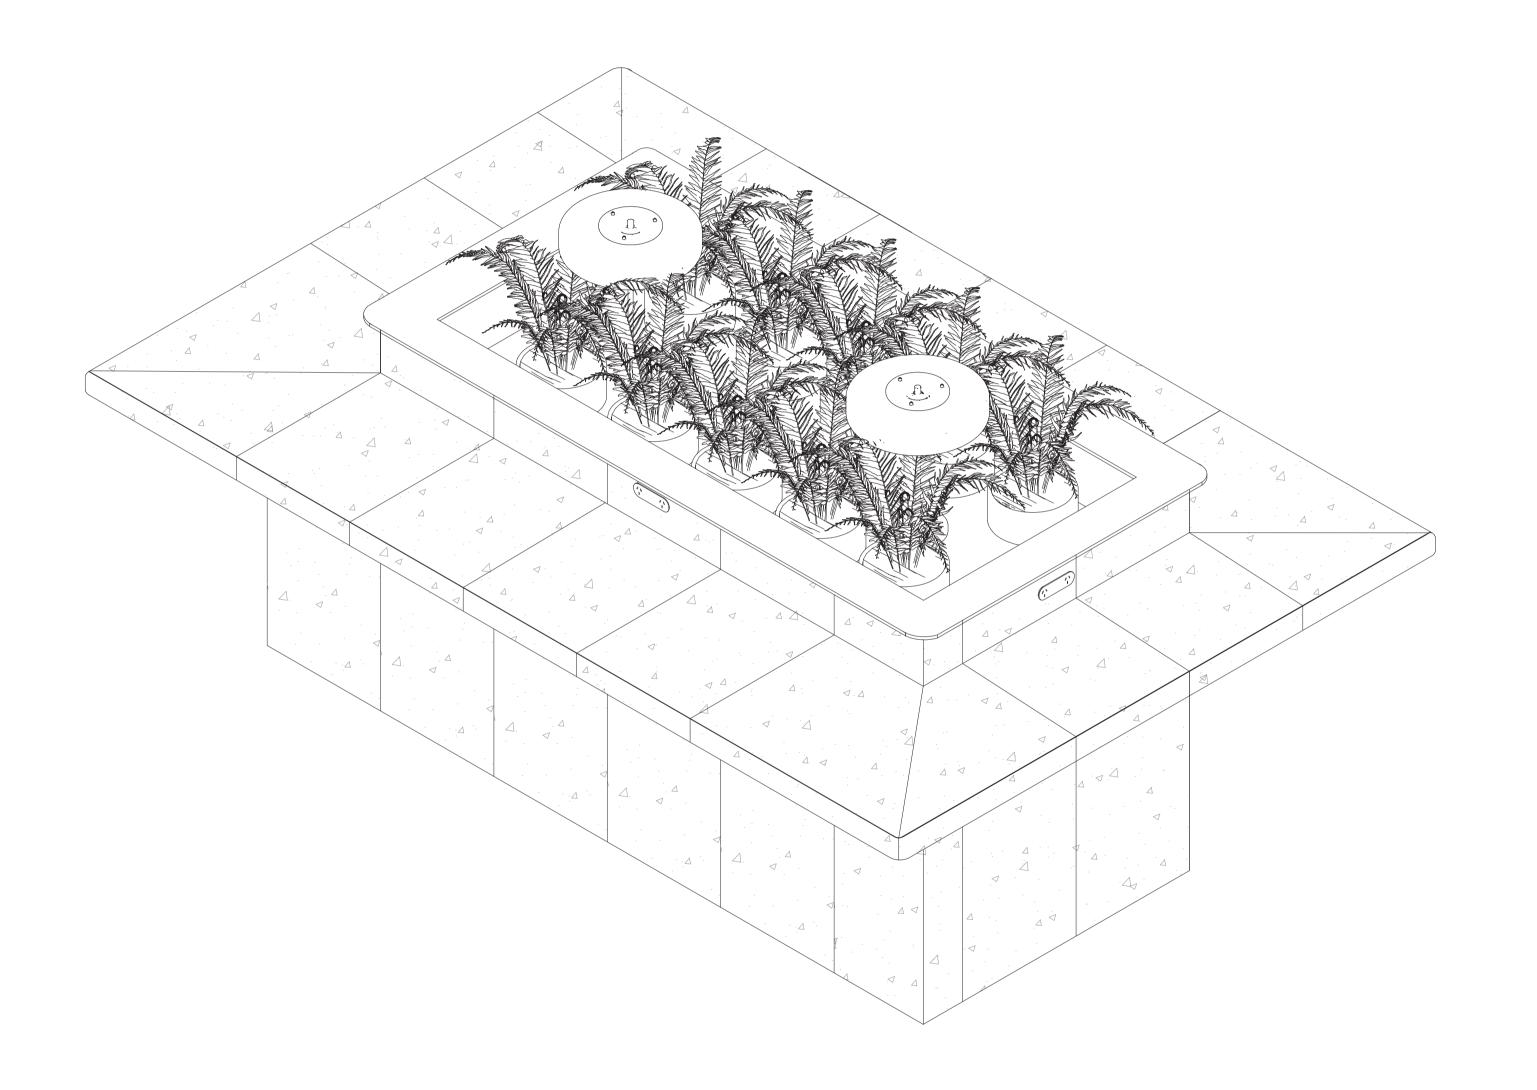

ISO OF SEATING COUNTER

SCALE 1:10

GENERAL NOTES

The contractor to be responsible for:
Verifying all drawings, specifications, dimensions and measurements as well as site, conditions and notifying the designer of all discrepancies and omissions before commencing the works.
Submitting samples and shop drawings for review and approval by designer before commencing works.
Ensuring that all work is keeping with all International building codes.
All necessary repairs, patching and cleaning of site during and after completition of works.
Verifying existing site conditions prior to submissions of quotations.
Not starting the construction unless these

Not starting the construction unless these drawings are signed approved.
All work specified on all drawings and specifications and supplying all necessary materials and labour required to complete all phases of work in accordance with the designer's

standards.
- All dimensions in millimeters

SPECIFIC NOTES:

	FURNITURE			
CODE	DISCRIPTION	CODE	DISCRIPTION	
WD1	WORKING DESK (HOT DESK AREA)	LC1	LOUNGE ARMCHAIR (LOUNGE AREA	
WC1	WORKING CHAIR (HOT DESK AREA)	BP2	BUILD IN ISLAND COUNTER (PANTR)	
WD2	WORKING DESK (PRIVATE OFFICE)	BP3	BUILD IN KITCHEN COUNTER (PANT	
WC2	WORKING CHAIR (PRIVATE OFFICE)	BT1	BUILD IN TV CABINET (METING ROC	
MT1	MEETING TABLE	BC2	BUILD IN CASHIER CAFE COUNTER CAFE)	
WC3	WORKING CHAIR (MEETING ROOM)	ВС3	BUILD IN CAFE COUNTER (CAFE)	
WT3	WORKING TABLE (SMALL PRIVATE OFFICE)	BC4	BUILD IN CAFE SHELVING(CAFE)	
WT4	WORKING TABLE (BIG PRIVATE OFFICE)	СВЗ	CABINET WITH PLANT ON TOP	
CA1	CAFE ARMCHAIR TYPE 1	FL1	FLOOR LAMP (LOUNGE)	
CT1	CAFE TABLE TYPE 1	PW1	PLANT PARTITION WALL	
CA2	CAFE ARMCHAIR TYPE 2	D01	MAIN GLASS SLIDING DOOR 2400mm	
CT2	CAFE TABLE TYPE 2	D02	SWING DOOR WITH METAL FRAME 900mm	
LT2	LOUNGE TABLE (SEATING AREA)	D03	SLIDING GLASS DOOR 1200mm	
BC1	BUILD IN RECEPTION COUNTER	D04	FOLDING DOOR 1200mm	
BP1	BUILD IN COUNTER (PANTRY)	D05	TOILET DOOR 900mm	
BB1	BUILD IN PHONE BOOTH	D06	TOILET ENTRANCE DOOR 900mm	
CC1	COUNTER CHAIR (PANTRY)	W01	GLASS WINDOW (FRONT BUILDING	
BS1	BUILD IN STAIR SEAT(PANTRY)	W02	2- GLASS WINDOW	
HC1	HANGING CHAIR (PANTRY)	W03	3- GLASS WINDOW	
HC2	HANGING CHAIR (NAP ROOM)	MATERIAL		
DB1	DAY BED (NAP ROOM)	SC1	WHITE GLOSSY FINISH CERAMIC TIL BACKSPLASH	
NB1	NAP BED (NAP ROOM)	MC1	20mm BLACK MARBLE TOP	
CB1	CABINET	MC2	20mm MDF BOARD WITH GRAY WOO LAMINATE ON TOP	
CB2	LOCKER	MC3	METAL CABINET HANDLE	
LS1	LOUNGE SOFA (LOUNGE AREA)	MC4	MDF BOARD TOEKICK WITH METAL SHEET FINSIHES	
	MACHINERY	MC5	15mm BLACK CHOCK BOARD	
KC1	SMALL FRIDGE	MC6	5mm TRANSPARENT GLASS	
KC2	COFFEE MACHINE	MC7	10MM MDF SHELVE BAORD	
КС3	MOUNTED CUP DISPENSER	MC8	90X45mm SUPPORTING TIMBER BLC	
KC5	CAKE MACHINE	MC9	W: 8mm, L:100, H: 1000mm, VERTICAL WOOD PANEL	



NO. DATE: REVISIONS:

ASSIGNMENT TITLE: DOCUMENTATION PROJECT (FINAL)

DRAWING TITLE: ISOMETRIC VIEW OF SEATING COUNTER

NAME: BUNHANGLINA YEA

COURSE: SYSTEM AND DOCUMENTATION 3


TERM: 1

ASSIGNMENT NO.:4

LECTURER : SOPHIE LUCAS

DATE: 10 MAY 2020

SCALE: 1:10

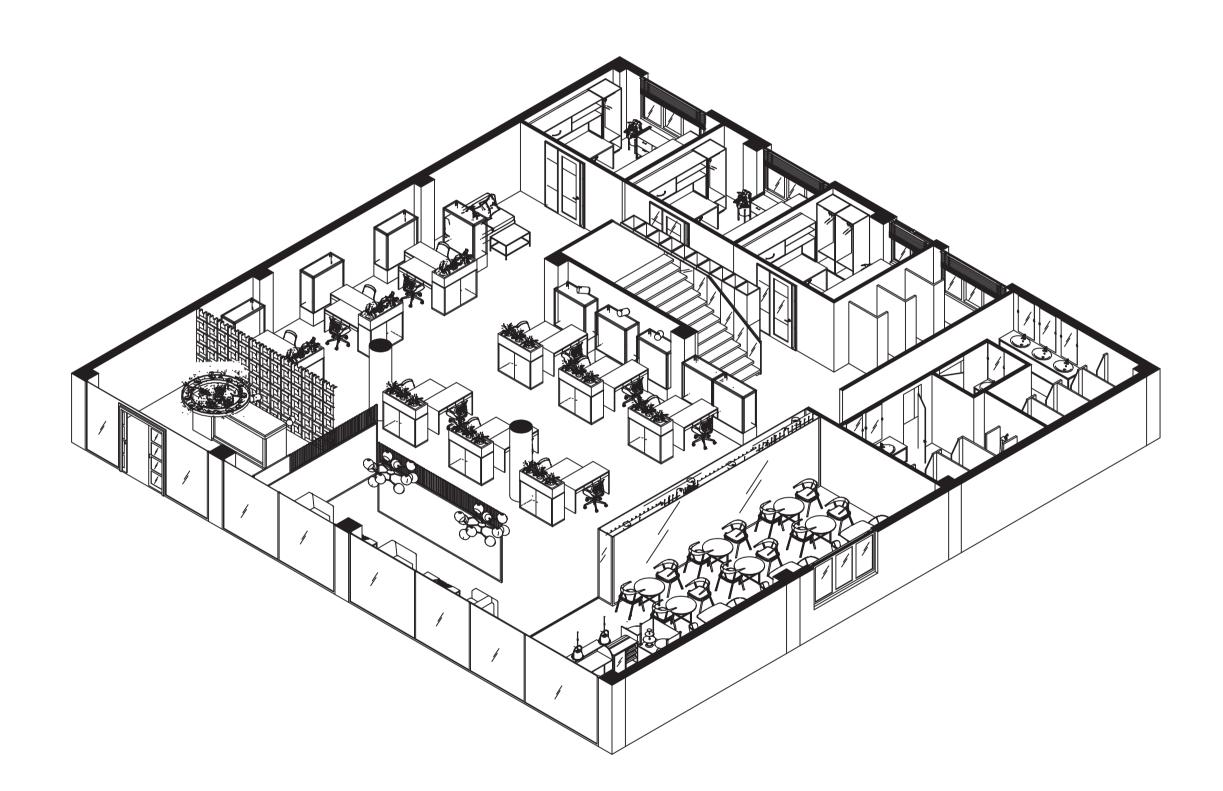

1 ISOMETRIC VIEW
22 SCALE 1:100

GENERAL NOTES The contractor to be responsible for: - Verifying all drawings, specifications, dimensions verifying all drawings, specifications, dimensions and measurements as well as site, conditions and notifying the designer of all discrepancies and omissions before commencing the works.
Submitting samples and shop drawings for review and approval by designer before commencing works. - Ensuring that all work is keeping with all International building codes. - All necessary repairs, patching and cleaning of site during and after completition of works. Verifying existing site conditions prior to submissions of quotations. Not starting the construction unless these drawings are signed approved.
All work specified on all drawings and specifications and supplying all necessary materials and labour required to complete all phases of work in accordance with the designer's standards. - All dimensions in millimeters SPECIFIC NOTES: DETAIL NO. SHEET NO. NO. DATE: REVISIONS: ASSIGNMENT TITLE: DOCUMENTATION PROJECT (FINAL) DRAWING TITLE: ISOMETRIC VIEW LEVEL 1 NAME: BUNHANGLINA YEA COURSE: SYSTEM AND DOCUMENTATION 3 TERM: 1 **ASSIGNMENT NO.:4** LECTURER : SOPHIE LUCAS

DATE: 10 MAY 2020

SCALE: 1:100